


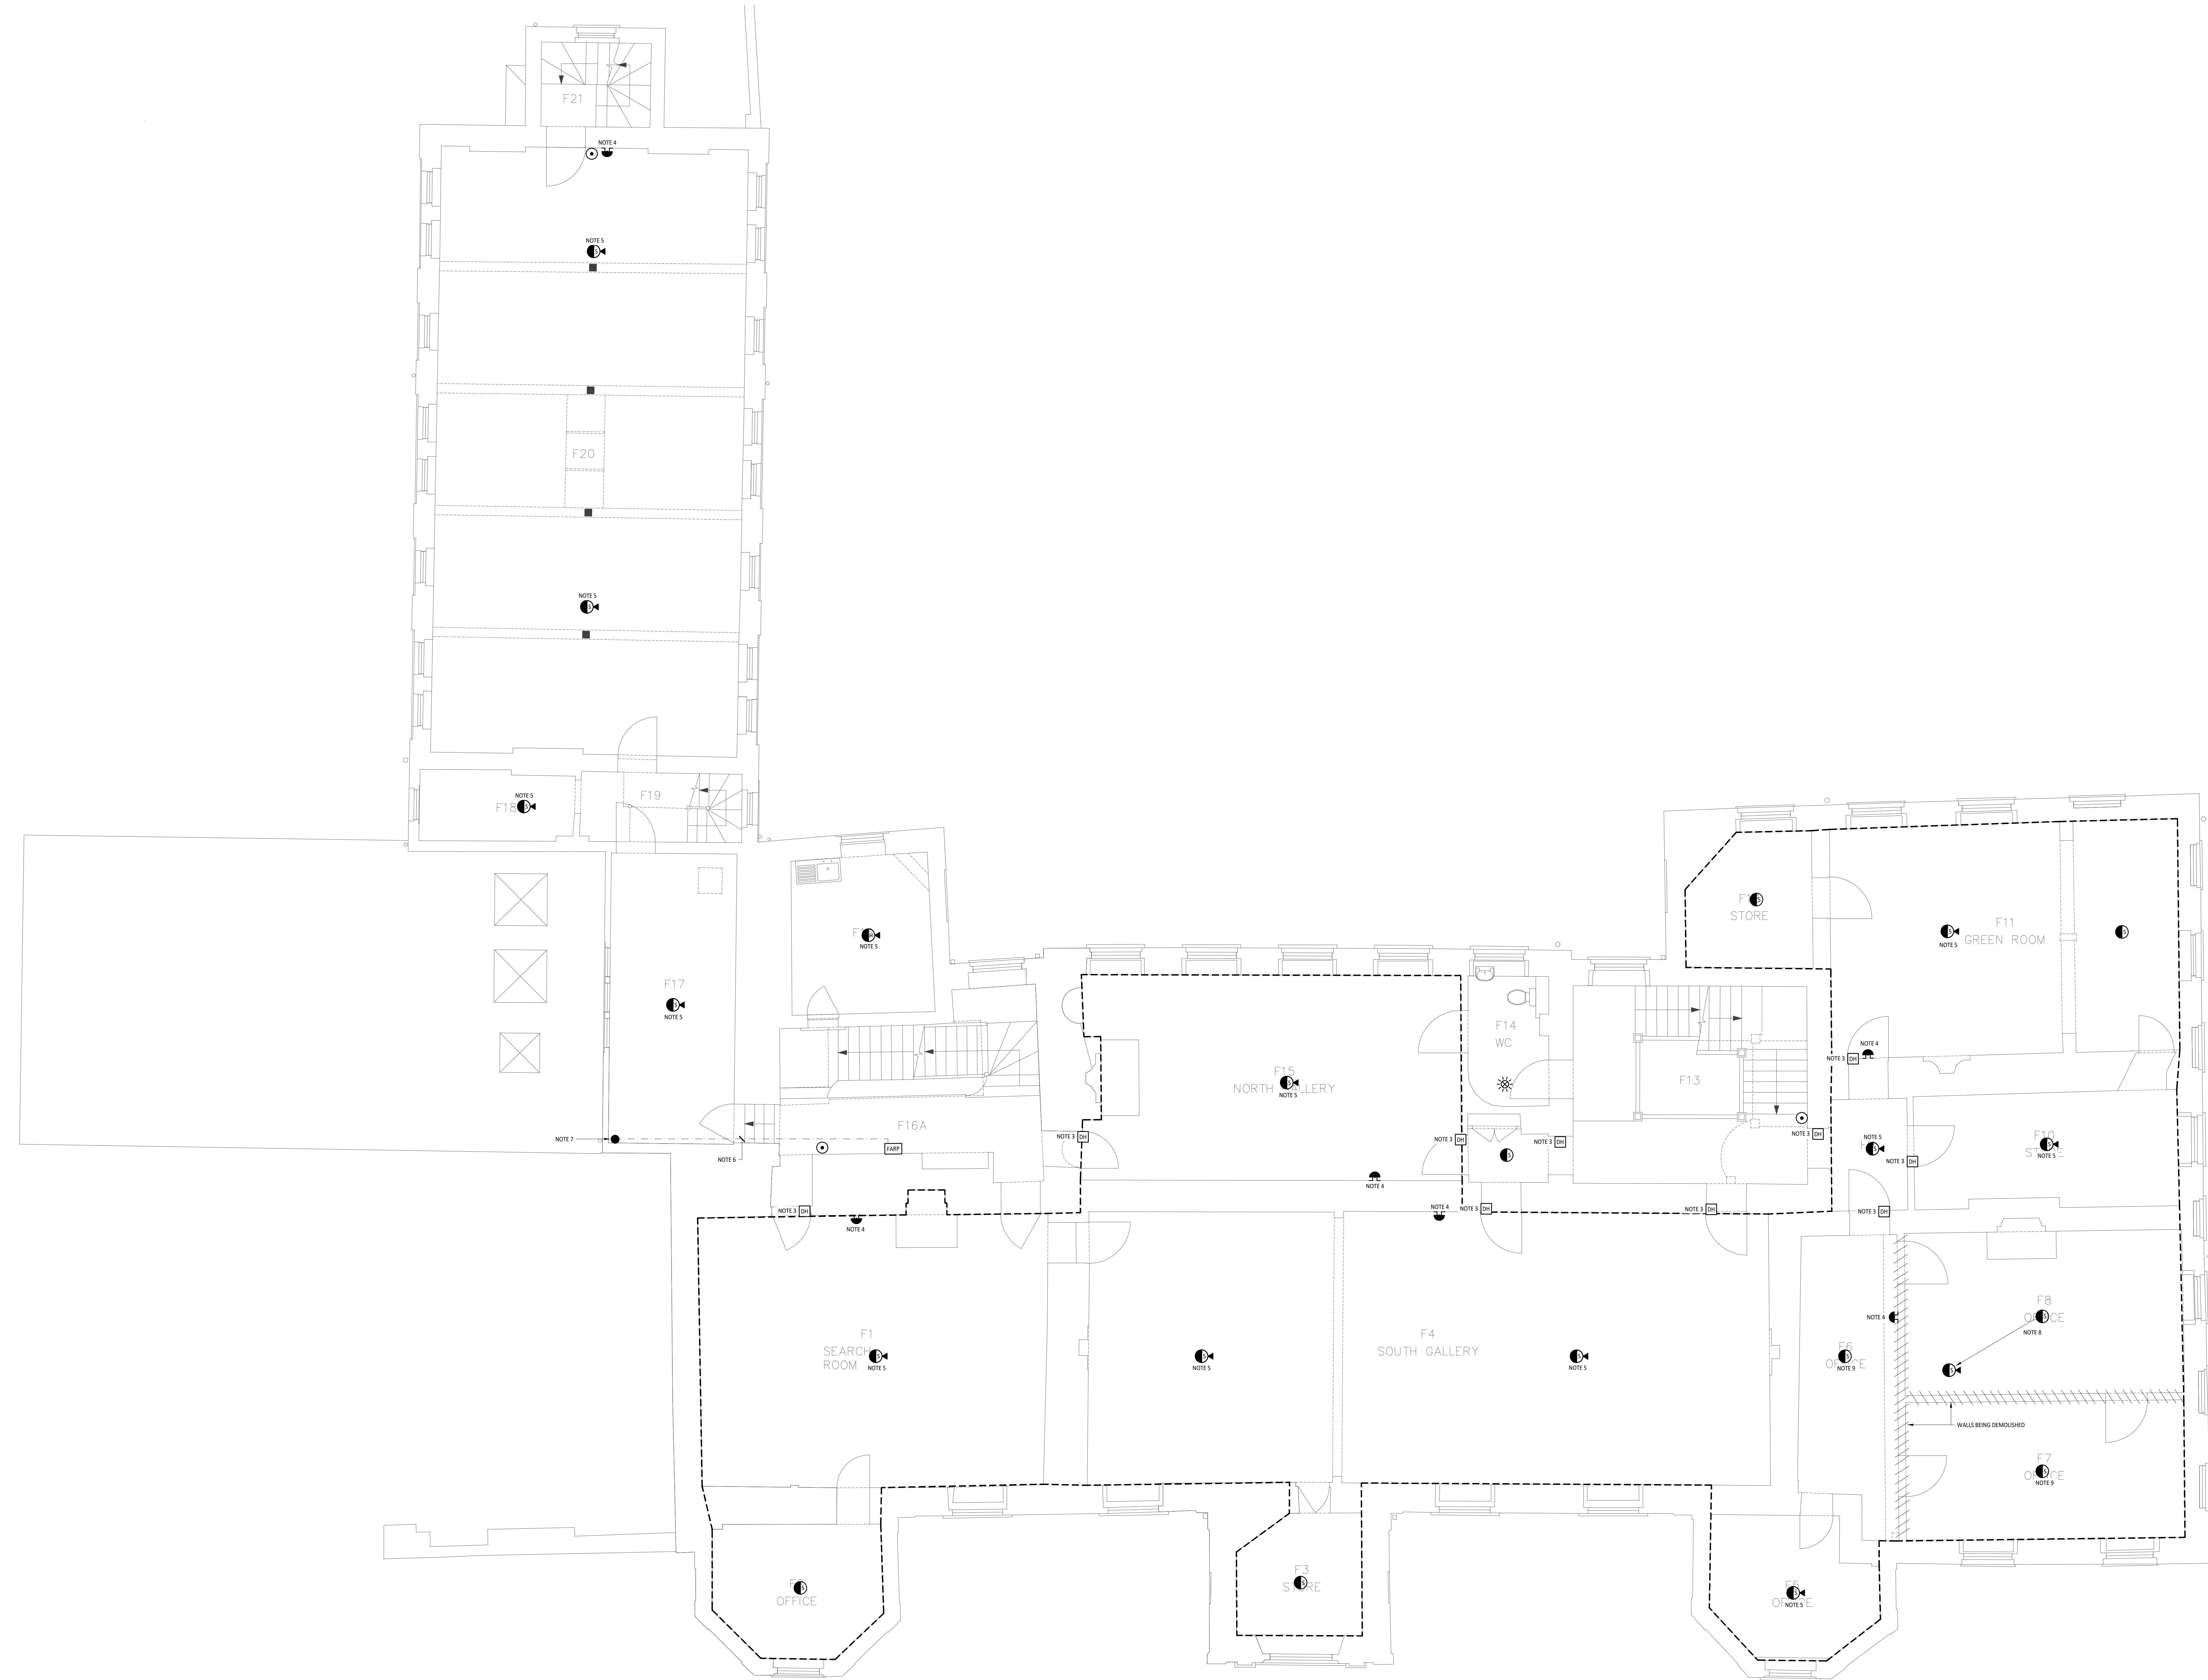

- DRAWING NOTES**
1. THIS SERVICES DRAWING IS TO BE READ IN CONJUNCTION WITH QODA'S, THE ARCHITECTURAL & STRUCTURAL ENGINEER'S SPECIFICATION / DRAWINGS.
 2. ALL EQUIPMENT SHOWN ON THIS DRAWING DENOTES LOCATIONS OF EXISTING EQUIPMENT. ALL DEVICES WILL BE REPLACED WITH NEW EQUIPMENT USING EXISTING LOCATIONS AND CABLING WHERE NOTED OTHERWISE.
 3. ALLOW TO CONNECT NEW OVERHEAD DOOR CLOSURES ON EACH DOOR LEAF AS APPLICABLE ONTO FIRE ALARM SYSTEM LOOP.
 4. EXISTING BELL & CABLING TO BE REMOVED.
 5. NEW LOOP SOUNDER ON NEW DETECTOR BASE.
 6. INTERRUNNING CABLES FROM EXISTING FIRE ALARM PANEL ON FIRST FLOOR TO NEW PANEL ON GROUND FLOOR.
 7. CABLES DROP DOWN TO GROUND FLOOR CORRIDOR.
 8. RELOCATE DETECTOR TO CENTRE OF NEW ROOM BEING CREATED AND ADD SOUNDER.
 9. REMOVE DEVICE FROM EXISTING FIRE ALARM LOOP.

INDICATES MEND AREA OF WORKS

DO NOT SCALE

Rev	Description	Date
T	TENDER ISSUE	27.02.2023



Client:

Haringey Council
Capital Projects & Property

Project:

Bruce Castle Museum & Park

Drawing Title:
Electrical Services
Fire Alarm Services - First Floor

Designed:	Drawn:	Checked:	Scale:	Paper Size:
S.L	S.L	M.N.T	1:50	A0

Drawing Number: 3156-QODA-XX-01-DR-E-0401 Rev. T