


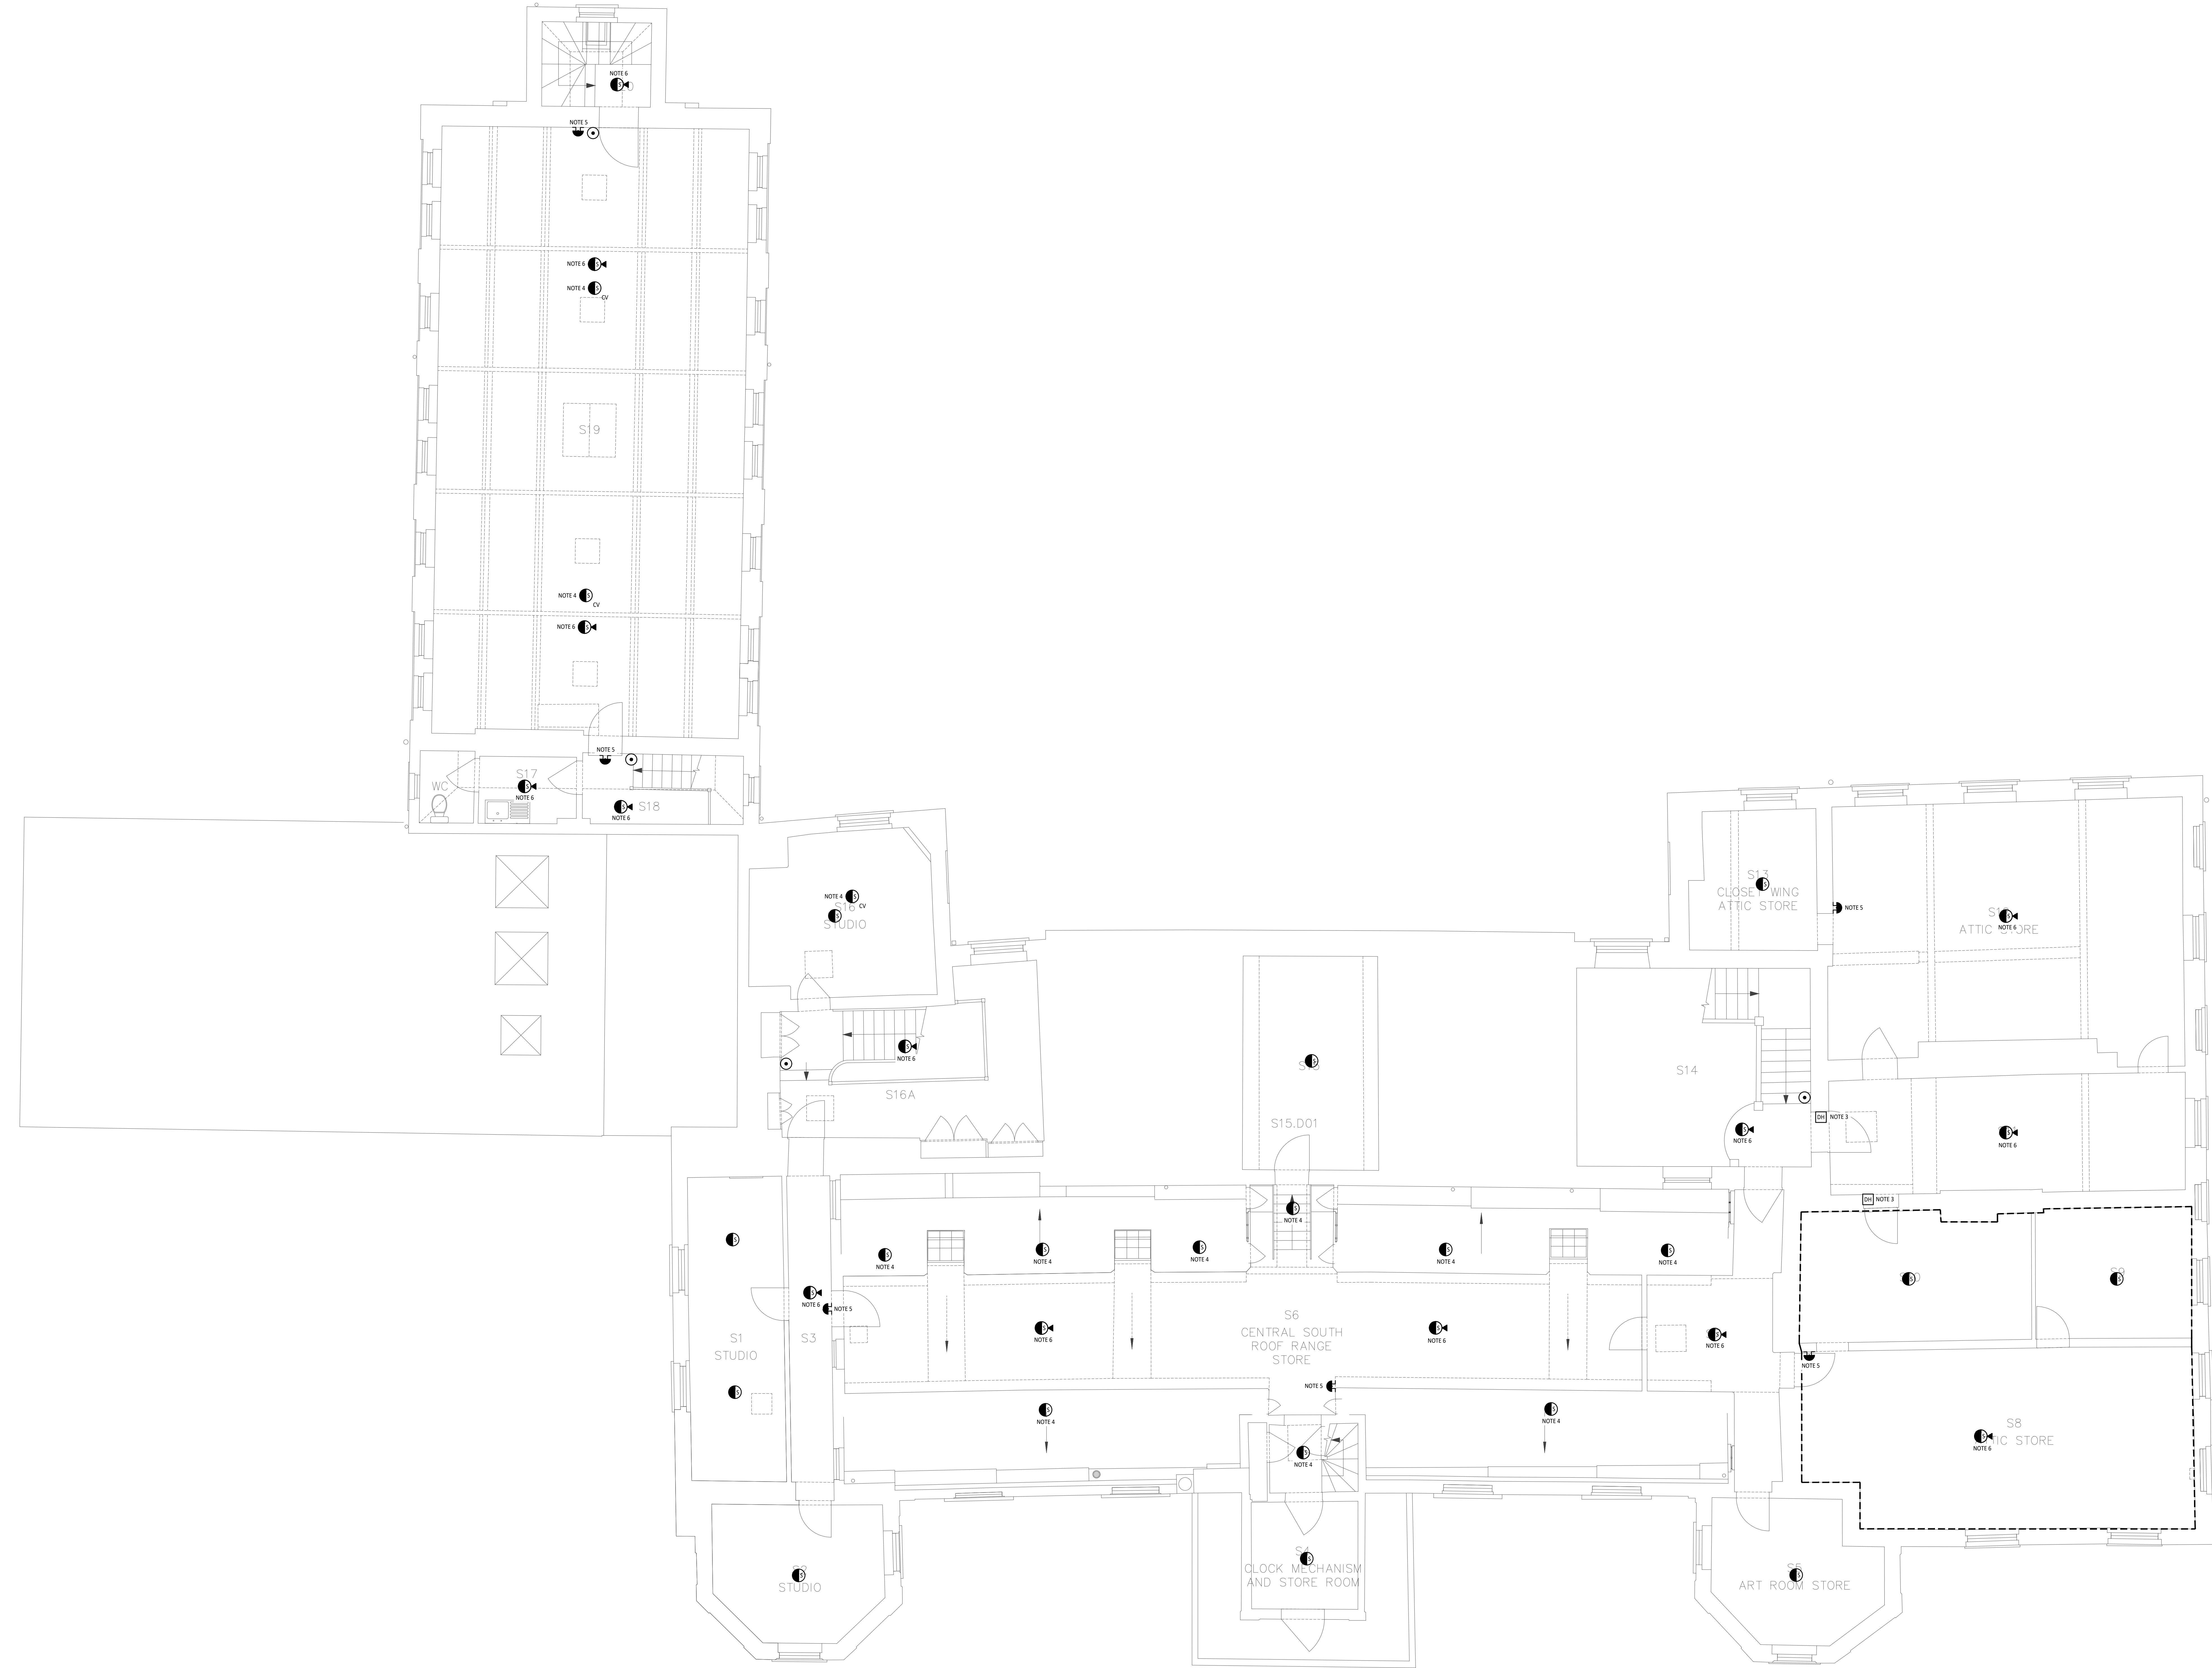

- DRAWING NOTES**
1. THIS SERVICES DRAWING IS TO BE READ IN CONJUNCTION WITH QODA'S, THE ARCHITECTURAL & STRUCTURAL ENGINEER'S SPECIFICATION / DRAWINGS.
 2. ALL EQUIPMENT SHOWN ON THIS DRAWING DENOTES LOCATIONS OF EXISTING EQUIPMENT. ALL DEVICES WILL BE REPLACED WITH NEW EQUIPMENT USING EXISTING LOCATIONS AND CABLING EXCEPT WHERE NOTED OTHERWISE.
 3. ALLOW TO CONNECT NEW OVERHEAD DOOR CLOSURE(S) ON EACH DOOR LEAF AS APPLICABLE ONTO FIRE ALARM SYSTEM.
 4. NEW DEVICE ADDED TO LOOP.
 5. EXISTING ROLL & CABLING TO BE REMOVED.
 6. NEW LOOP SOUNDER ON NEW DETECTOR BASE.

INDICATES MEND AREA OF WORKS

DO NOT SCALE

T TENDER ISSUE 27.02.2023

Rev Description Date



Client:

Haringey Council
Capital Projects & Property

Project:

Bruce Castle Museum & Park

Drawing Title:
Electrical Services
Fire Alarm Services - Second Floor

Designed: S.L. Drawn: S.L. Checked: M.N.T. Scale: 1:50 Paper Size: A0

Drawing Number: 3156-QODA-XX-02-DR-E-0401 Rev. T