


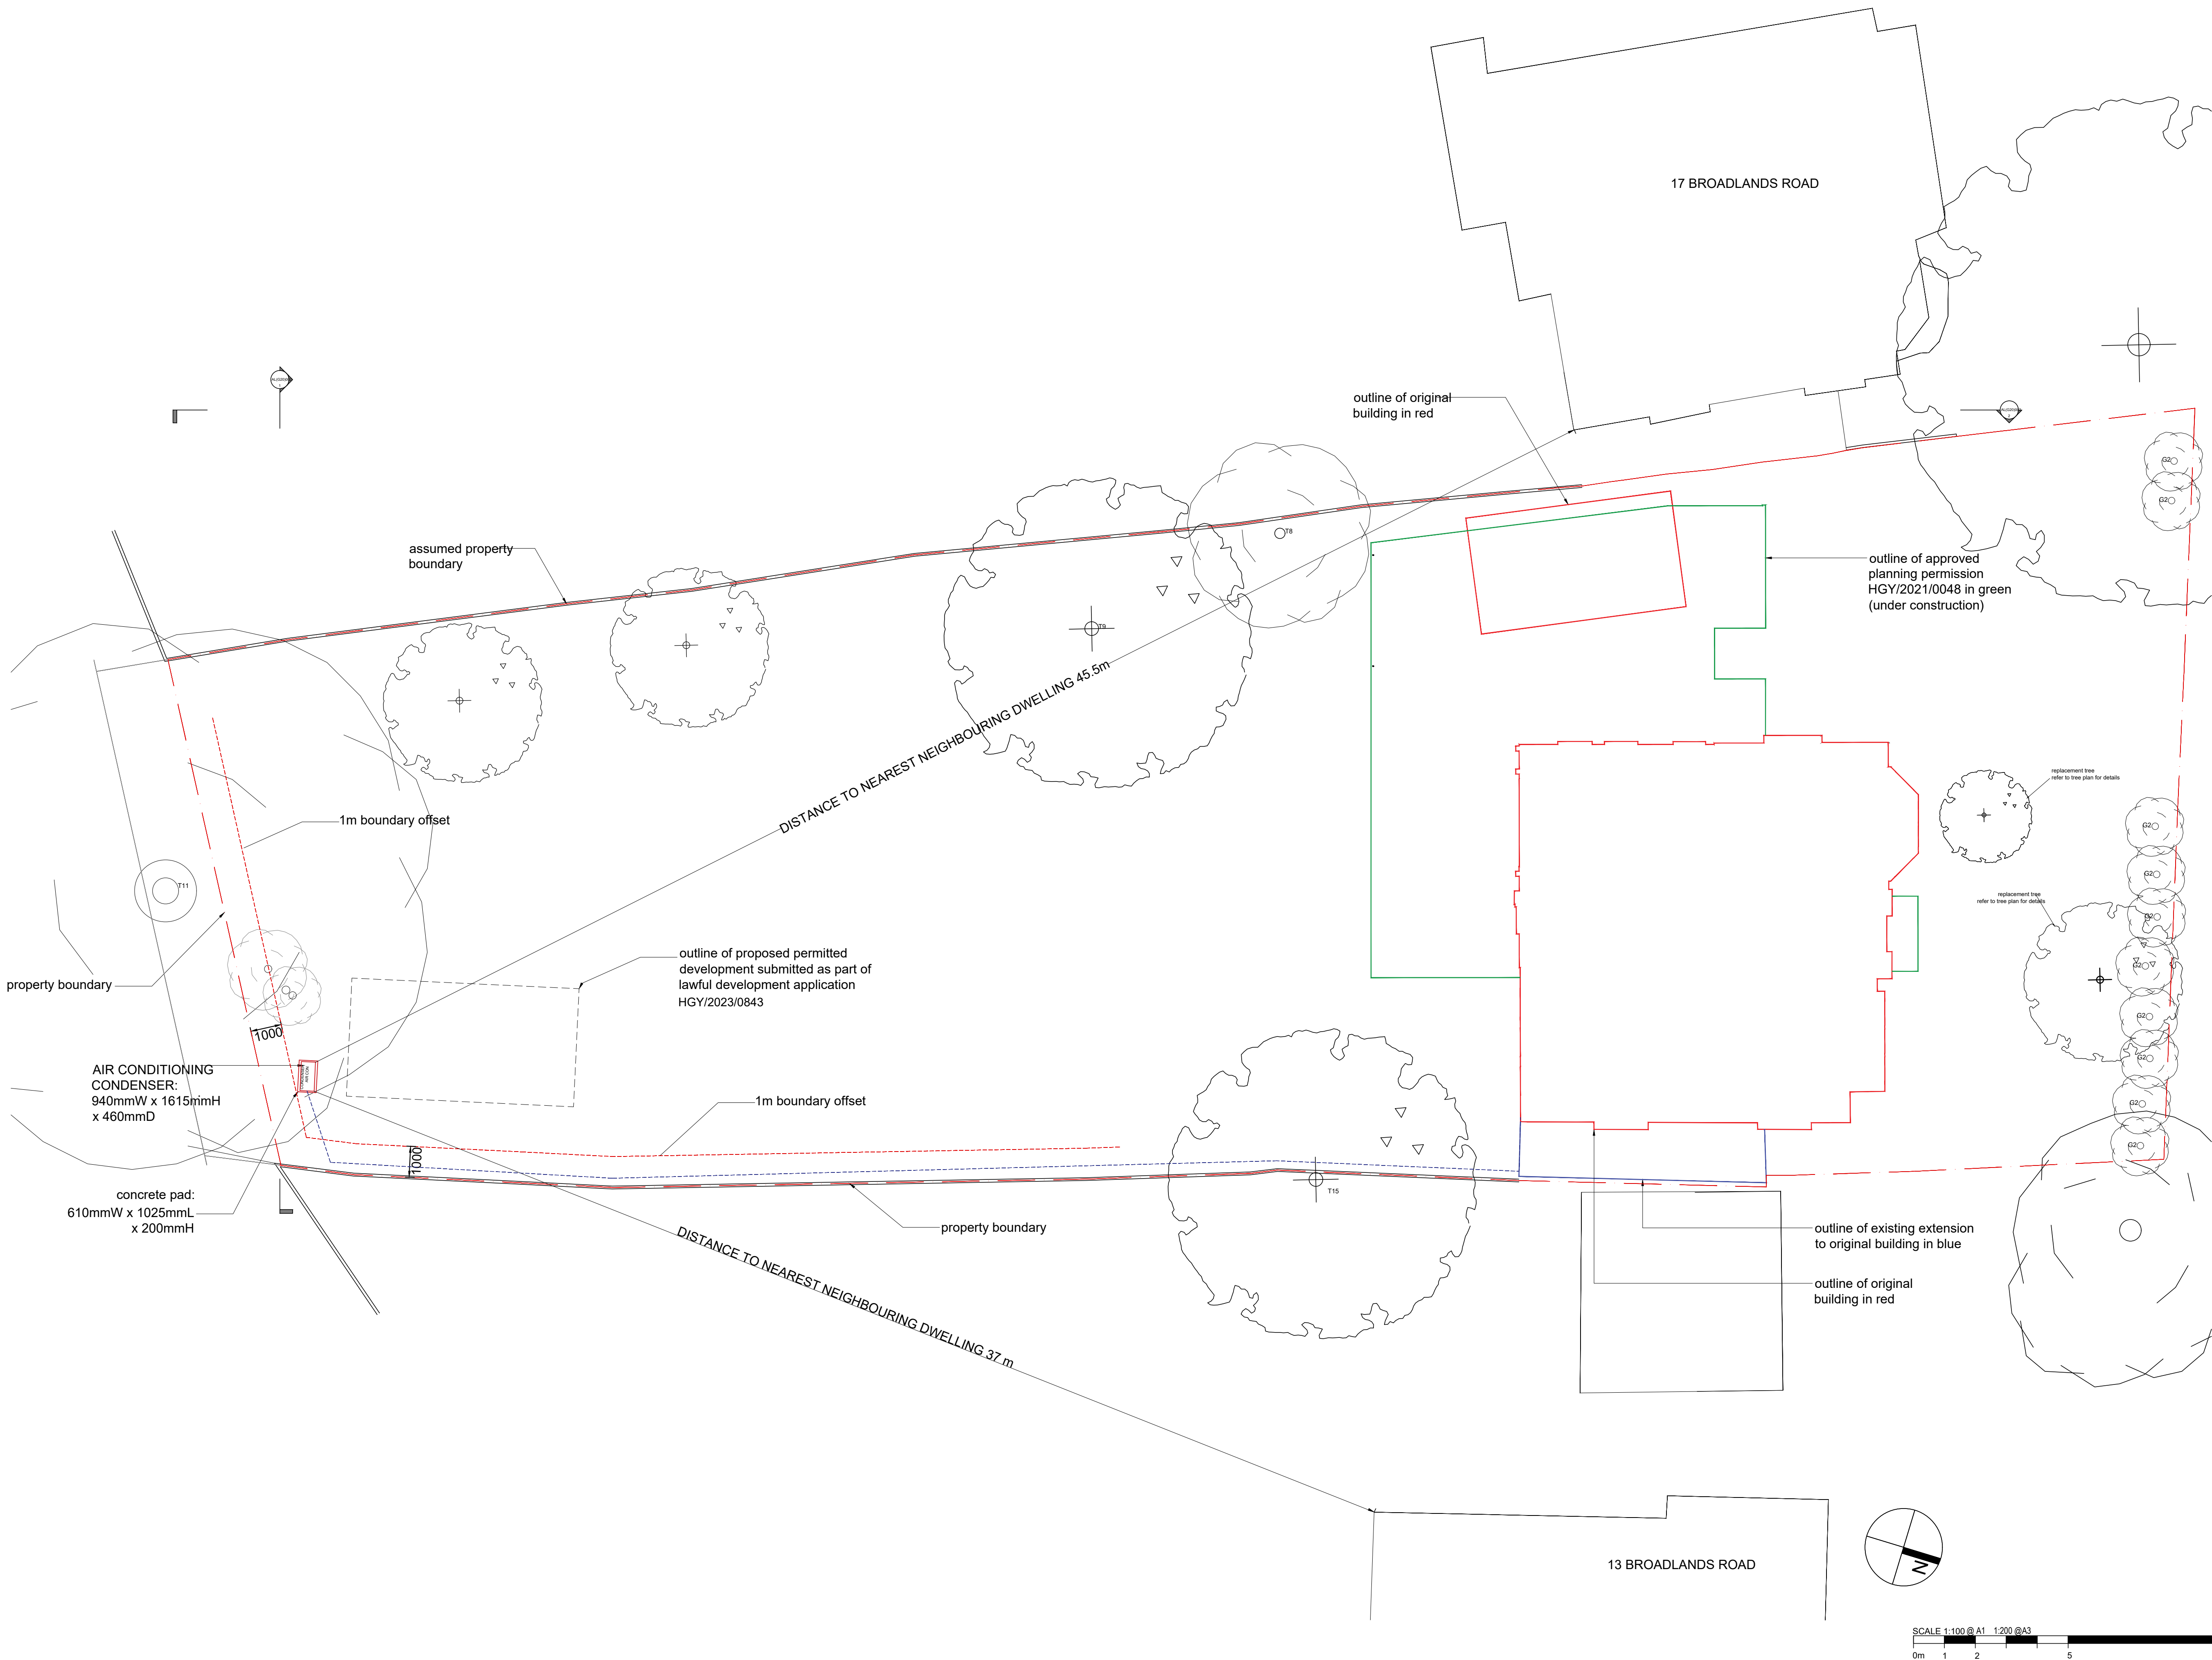

A. REMOVED ASHP CONDENSER UNITS 10.01.24

PLANNING ISSUE



15 Broadlands Rd, N6 4AE

TITLE: GROUND FLOOR PLAN
SCALE: 1:100 @ A1, 1:200 @ A3
DATE: JANUARY 2024

AL(G00)051

A