



©2020 Cellnex
All rights reserved. No part of this publication may be reproduced, stored in a retrieval system or transmitted in any form or by any means (Electronic, Mechanical, Photocopying, Recording or otherwise), without the prior written consent of the Company.

NOTES

UNDERGROUND SERVICES
UNDERGROUND SERVICES ARE INDICATIVE ONLY.
POSITIONS SHOULD BE CONFIRMED ON SITE PRIOR TO ANY DEVELOPMENT

DRAINAGE	-----
DUCTS	-----
FEEDERS	-----
FENCE PLAN	-----
GAS	-----
LIGHTNING PROTECTION - EARTHING	-----
POWER	-----
SERVICES UNKNOWN	-----
TELECOMS	-----
WATER	-----

ACCESS ARRANGEMENTS

KEYS:-	ARQIVA GATE KEY	▲
	B KEY	▲
	C KEY	▲
	LEGGE KEY	▲

SURVEY REQUIRED TO CONFIRM ACCESS KEYS FOR REMAINING ROOMS AND SITE ENTRANCE

8	COM-0016248	15/02/24	ARC	ARC
7	COM-0020062	17/10/23	MCD	MCD
6	COM-0020062	23/01/23	GBC	GBC
5	COM-0020062	22/12/22	GBC	GBC
4	COM-0020062	21/12/22	GBC	GBC
ISS	REVISION	DATE	DRN	APP



CELLNEX UK
R+, 4TH FLOOR, 2 BLA GRAVE STREET, READING, RG1 1AZ
Tel. 020 4526 8553

SITE No **302728**
TOTTENHAM LORDSHIP LANE
TIVOLI COACHWORKS
52 LORDSHIP LANE
TOTTENHAM
GREATER LONDON 1
N17 7QG

NGR **TQ 33340 90630**

OS GRID **533340 190630**

TITLE
SITE PLAN
EXISTING

SCALE **1:100**

DRAWN **KG** **09/04/20**

APPROVED **ARC** **15/02/24**

DRG No. **302728-00-000-MD008** Sheet 1 of 1 Rev

302728-00-000-MD008 **8**

GROUND LEVEL
0.0m

H3G & BTEE 3No. WT8565-19-AA ANTENNAS AT 9.7m MEAN, 0°, 120° & 240° E.T.N. I.D. No. 446517, 446518 & 446519 INSTALLED ON SUPPORT POLES VIA EXISTING 6No. Z-BRACKETS (2 PER SECTOR)

BTEE 3No. LGP18521 (1800) MHA's INSTALLED ON SUPPORT POLES

H3G & BTEE 3No.TMA2053F03V2-4 (18/21) MHA's INSTALLED ON SUPPORT POLES

H3G & BTEE 3No. ATR4518R4 ANTENNAS AT 9.7m MEAN, 0°, 120° & 240° E.T.N. I.D. No. 446514, 446515 & 446516 INSTALLED ON SUPPORT POLES VIA EXISTING 6No. 3263 MAFI BRACKETS (2 PER SECTOR)

H3G 3No. E15R02P11 (800) MHA's INSTALLED ON ANTENNA SUPPORT POLES

H3G & BTEE 1No. SHF 0.3m HP DISH AT 8.2m MEAN, 230° E.T.N. I.D. No. 446520 INSTALLED ON SUPPORT POLE VIA EXISTING 2No. OFFSET BRACKETS

BTEE 1No. Mk1 BOB INSTALLED ON VERTICAL CABLE LADDER

BTEE 1No. BTS3900A CABINET I.D. No. XXXXXXXXXXXX INSTALLED ON STEEL GRILLAGE

450mm WIDE CABLE LADDER

ROOF LEVEL
+4.0m

ROOF LEVEL
+5.2m

ROOF LEVEL
+6.5m

5.0m HIGH STUB TOWER INSTALLED ON STEEL GRILLAGE

450mm WIDE OVERHEAD CABLE LADDER

H3G & BTEE 1No. TX CABINET I.D. No. XXXXXXXXXXXX INSTALLED ON STEEL GRILLAGE

BTEE 3No. 3262 (2600) RRU's INSTALLED ON UNISTRUT FRAME MOUNTED ON VERTICAL CABLE LADDER

H3G & BTEE 1No. FCOA CABINET I.D. No. XXXXXXXXXXXX INSTALLED ON STEEL GRILLAGE

H3G & BTEE 1No. PSU CABINET I.D. No. XXXXXXXXXXXX INSTALLED ON STEEL GRILLAGE

BTEE 1No. Mk1 BOB INSTALLED MOUNTED ON VERTICAL CABLE LADDER

AC DISTRIBUTION BOARD FIXED TO HANDRAIL

 
H3G & BTEE 3No. ROTARY ISOLATORS FIXED TO HANDRAIL


H3G 1No. OFS5906 CABINET I.D. No. XXXXXXXXXXXX C/W 3No. 5501 (18/21) RRU's & 2No. 5301 RRU's (800) INSTALLED ON STEEL GRILLAGE

1100mm HIGH FREESTANDING HANDRAIL

ROOFTOP ACCESS DOOR

ROOF LEVEL
+8.5m



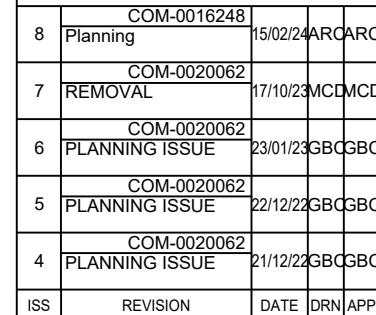

NGR	TQ 33340 90630
-----	----------------

TITLE	
-------	--

SCALE 1:100


DRAWN	KG	09/04/20
-------	----	----------

APPROVED	ARC	15/02/24
----------	-----	----------

DRG No.	Sheet 1 of 1	Rev
---------	--------------	-----

202728	00 002	MD008	8
--------	--------	-------	---

302726-00-002-MD006	8
A0	

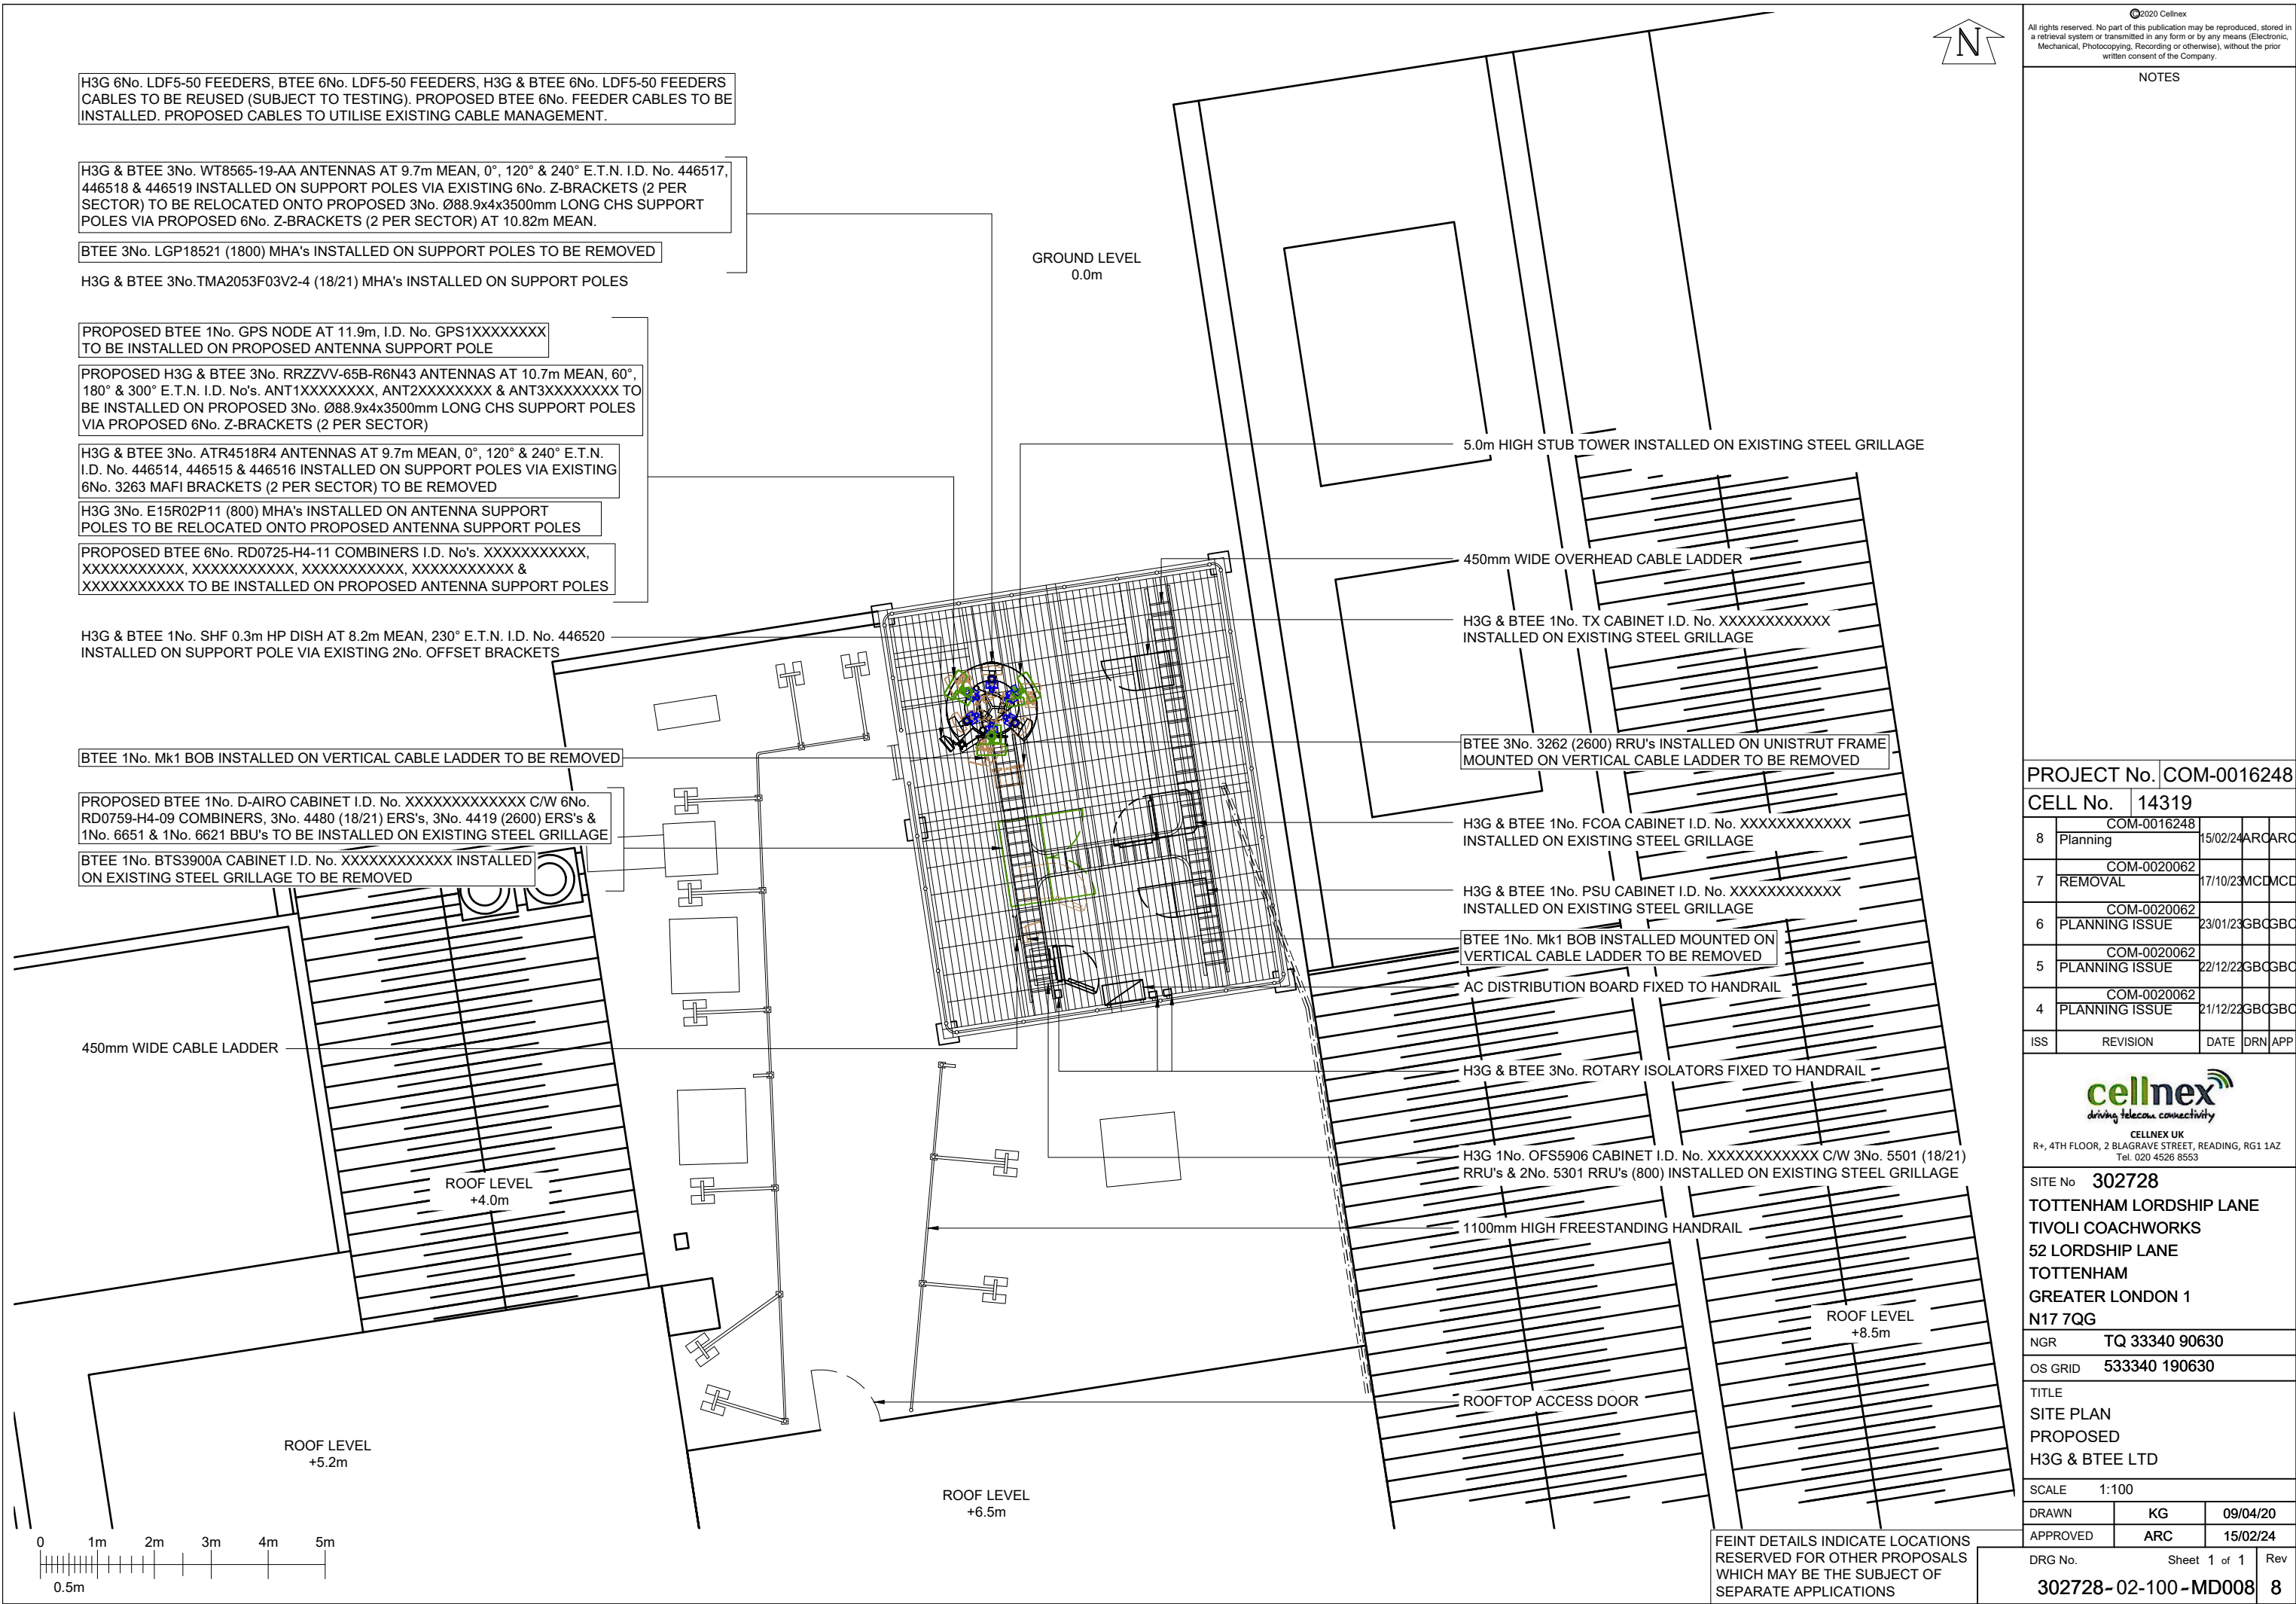

©2020 Cellnex
All rights reserved. No part of this publication may be reproduced, stored in a retrieval system or transmitted in any form or by any means (Electronic, Mechanical, Photocopying, Recording or otherwise), without the prior written consent of the Company.

NOTES				
PROJECT No. COM-0016248				
CELL No. 14319				
8	Planning	COM-0016248	15/02/24	ARC
7	REMOVAL	COM-0020062	17/10/23	MCD
6	PLANNING ISSUE	COM-0020062	23/01/23	GBC
5	PLANNING ISSUE	COM-0020062	22/12/22	GBC
4	PLANNING ISSUE	COM-0020062	21/12/22	GBC
ISS	REVISION	DATE	DRN	APP



CELLNEX UK
R+, 4TH FLOOR, 2 BLA GRAVE STREET, READING, RG1 1AZ
Tel. 020 4526 8553

SITE No. 302728
TOTTENHAM LORDSHIP LANE
TIVOLI COACHWORKS
52 LORDSHIP LANE
TOTTENHAM
GREATER LONDON 1
N17 7QG

NGR TQ 33340 90630

OS GRID 533340 190630

TITLE
SITE PLAN
PROPOSED
H3G & BTEE LTD

SCALE 1:100

DRAWN	KG	09/04/20
APPROVED	ARC	15/02/24

DRG No. Sheet 1 of 1 Rev

302728-02-100-MD008 8



©2020 Cellnex
All rights reserved. No part of this publication may be reproduced, stored in a retrieval system or transmitted in any form or by any means (Electronic, Mechanical, Photocopying, Recording or otherwise), without the prior written consent of the Company.

NOTES

PROJECT No. COM-0016248

CELL No. 14319

8	COM-0016248 Planning	15/02/24	ARC	ARC
7	COM-0020062 REMOVAL	17/10/23	MCD	MCD
6	COM-0020062 PLANNING ISSUE	23/01/23	GBC	GBC
5	COM-0020062 PLANNING ISSUE	22/12/22	GBC	GBC
4	COM-0020062 PLANNING ISSUE	21/12/22	GBC	GBC
ISS	REVISION	DATE	DRN	APP



CELLNEX UK
R+, 4TH FLOOR, 2 BLA GRAVE STREET, READING, RG1 1AZ
Tel. 020 4526 8553

SITE No 302728
TOTTENHAM LORDSHIP LANE
TIVOLI COACHWORKS
52 LORDSHIP LANE
TOTTENHAM
GREATER LONDON 1
N17 7QG

NGR TQ 33340 90630

OS GRID 533340 190630

TITLE
EQUIPMENT PLAN
PROPOSED
H3G & BTEE LTD

SCALE 1:50


DRAWN KG 09/04/20

APPROVED ARC 15/02/24

DRG No. Sheet 1 of 1 Rev


302728-02-101-MD008 8

FEINT DETAILS INDICATE LOCATIONS
RESERVED FOR OTHER PROPOSALS
WHICH MAY BE THE SUBJECT OF
SEPARATE APPLICATIONS

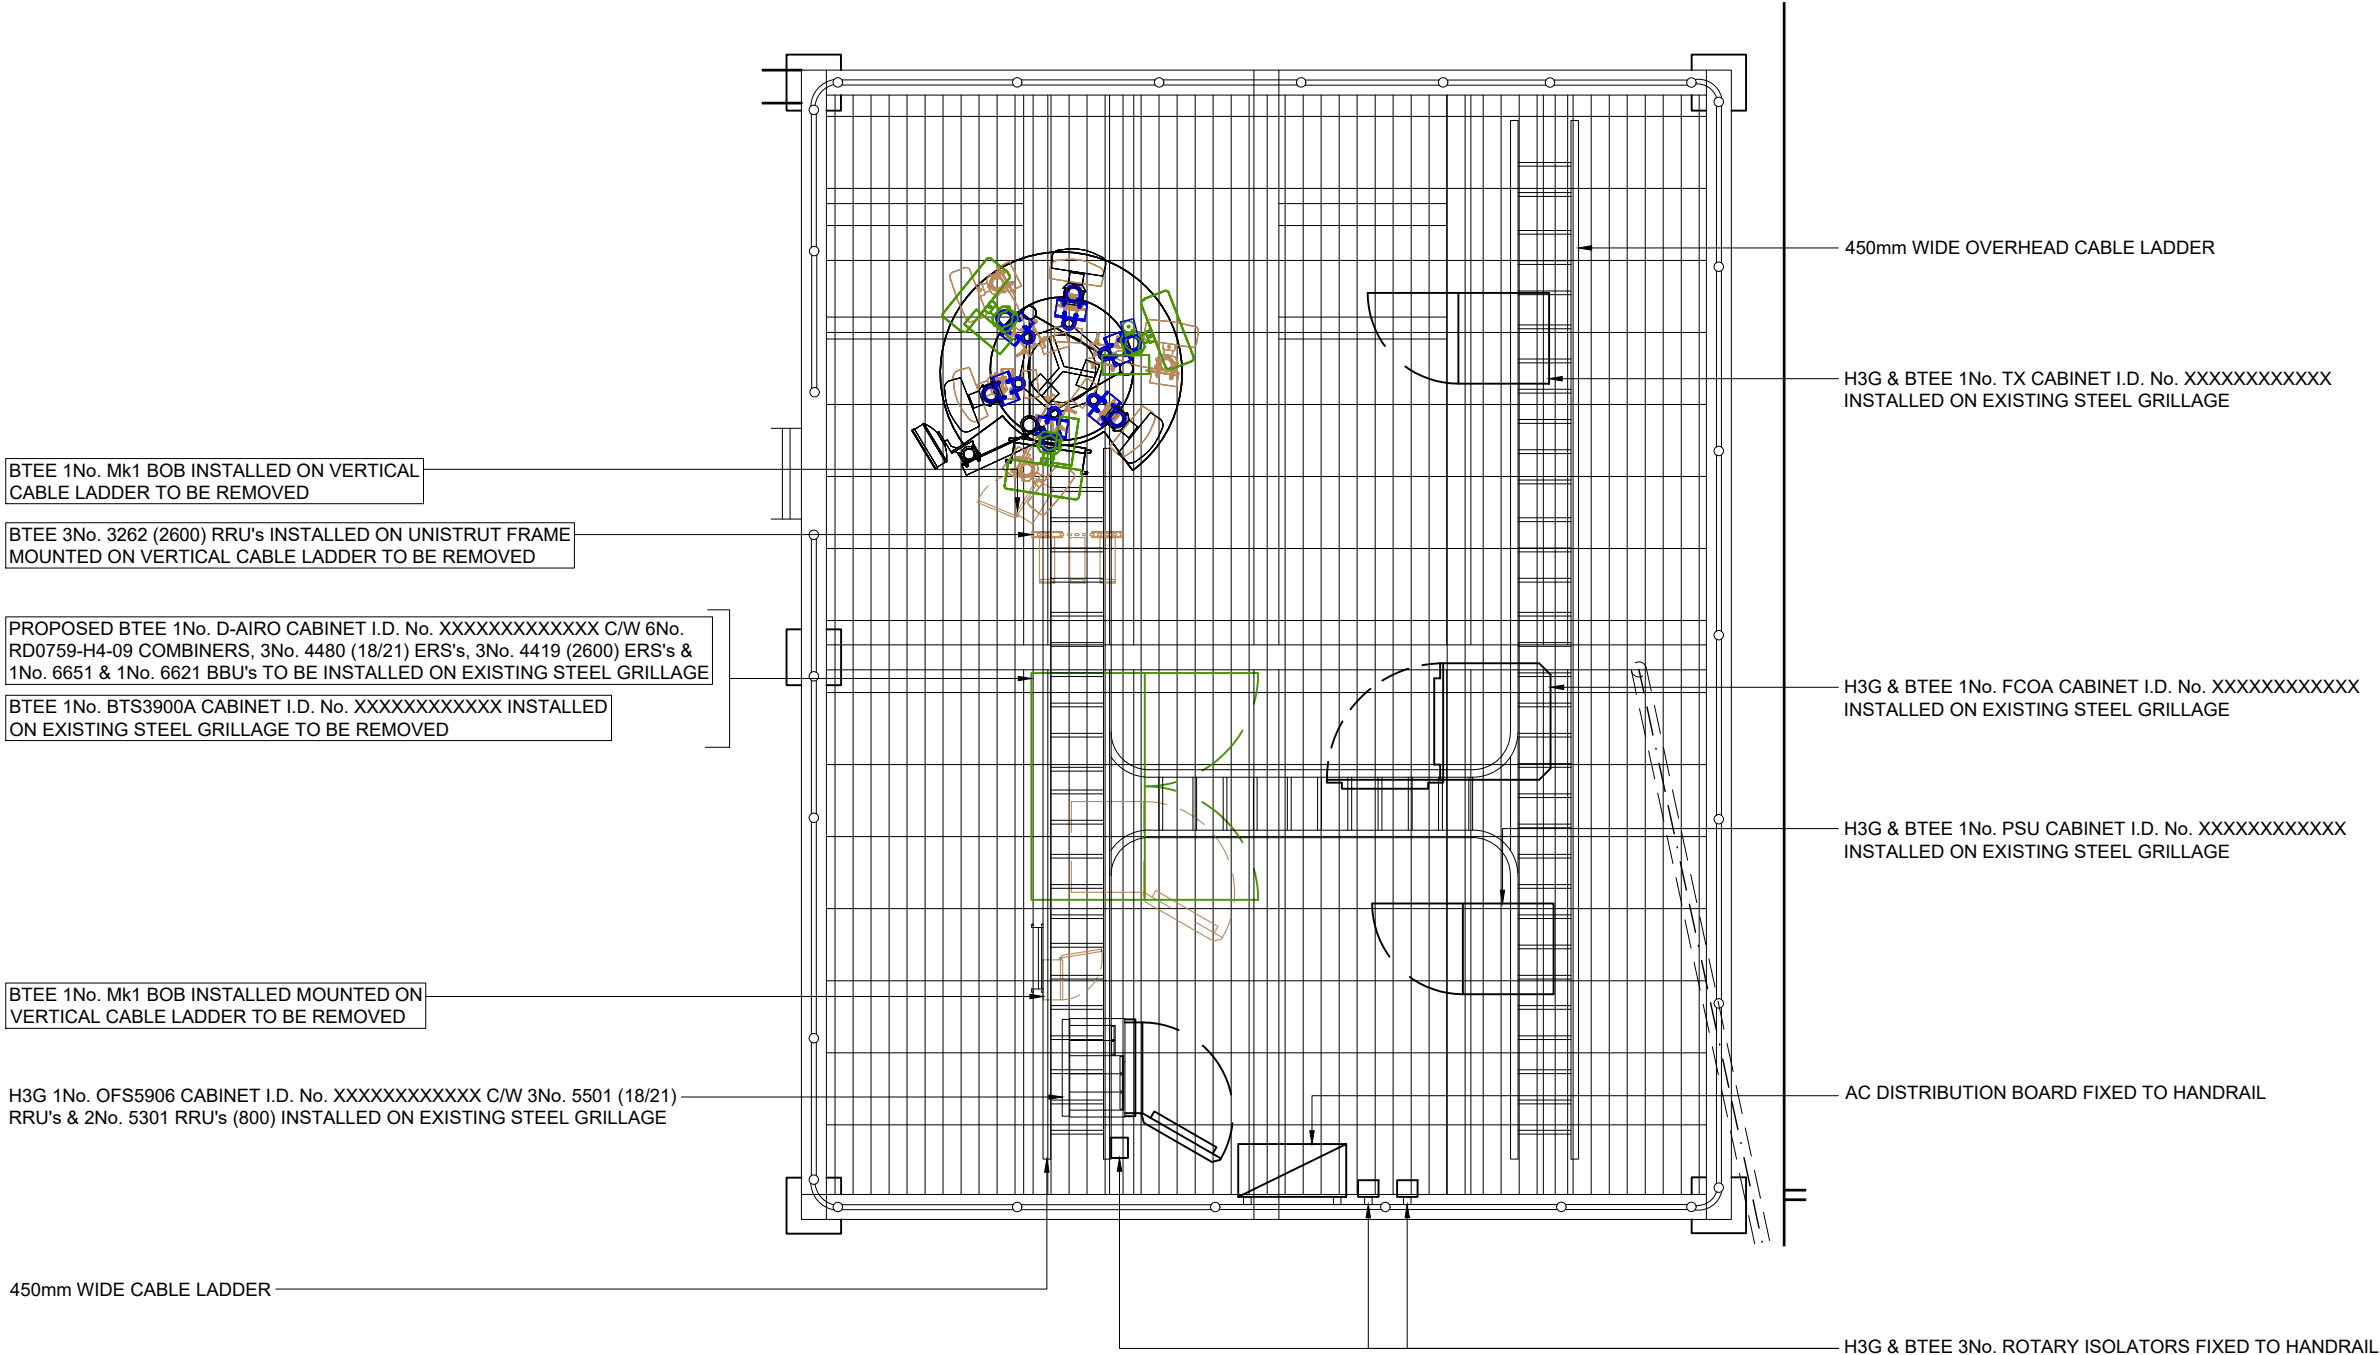

H3G & BTEE EQUIPMENT PLAN



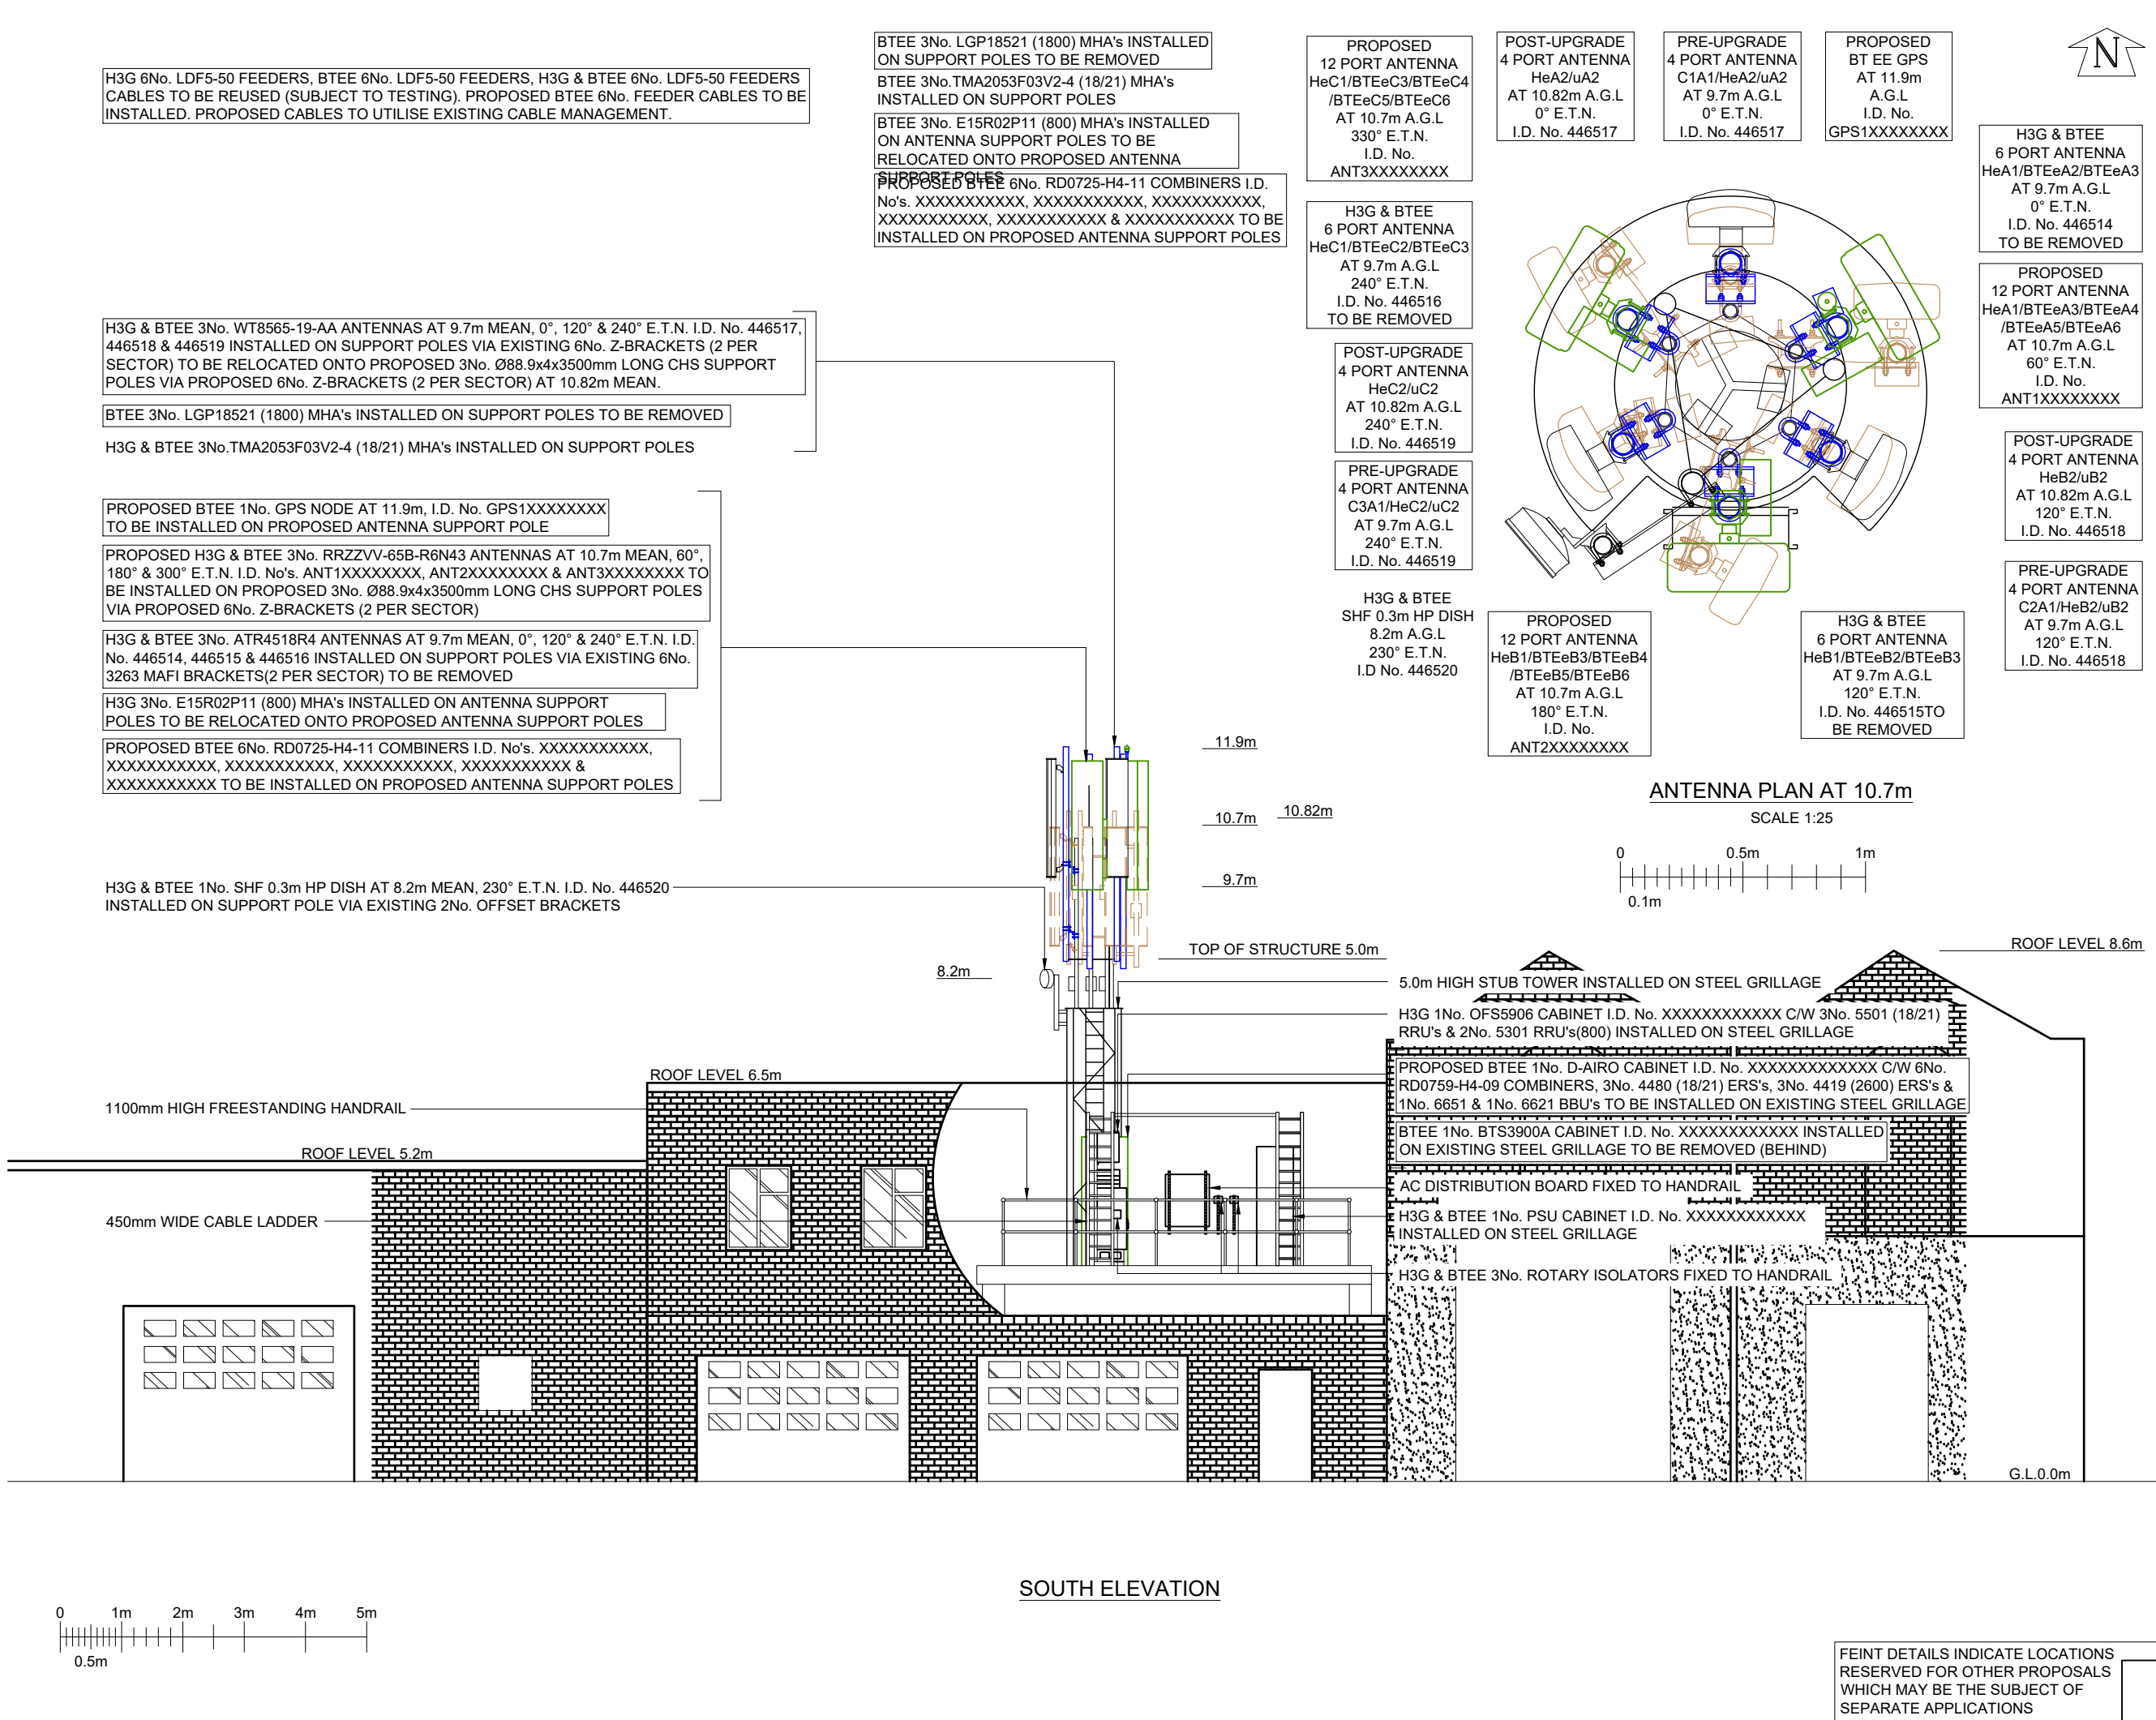

©2020 Cellnex
All rights reserved. No part of this publication may be reproduced, stored in a retrieval system or transmitted in any form or by any means (Electronic, Mechanical, Photocopying, Recording or otherwise), without the prior written consent of the Company.

NOTES

PROJECT No.		COM-0016248	
CELL No.		14319	
8	COM-0016248 Planning	15/02/24	ARC
7	COM-0020062 REMOVAL	17/10/23	MCD
6	COM-0020062 PLANNING ISSUE	23/01/23	GBC
5	COM-0020062 PLANNING ISSUE	22/12/22	GBC
4	COM-0020062 PLANNING ISSUE	21/12/22	GBC
ISS	REVISION	DATE	DRN APP

cellnex

driving telecom connectivity

CELLNEX UK
R+, 4TH FLOOR, 2 BLA GRAVE STREET, READING, RG1 1AZ
Tel. 020 4526 8553

SITE No

302728

TOTTENHAM LORDSHIP LANE

TIVOLI COACHWORKS

52 LORDSHIP LANE

TOTTENHAM

GREATER LONDON 1

N17 7QG

NGR

TQ 33340 90630

OS GRID

533340 190630

TITLE

ELEVATION

PROPOSED

H3G & BTEE LTD

SCALE

1:100

DRAWN

KG

09/04/20

APPROVED

ARC

15/02/24

DRG No.

Sheet 1 of 1

Rev

302728-02-150-MD008

8