
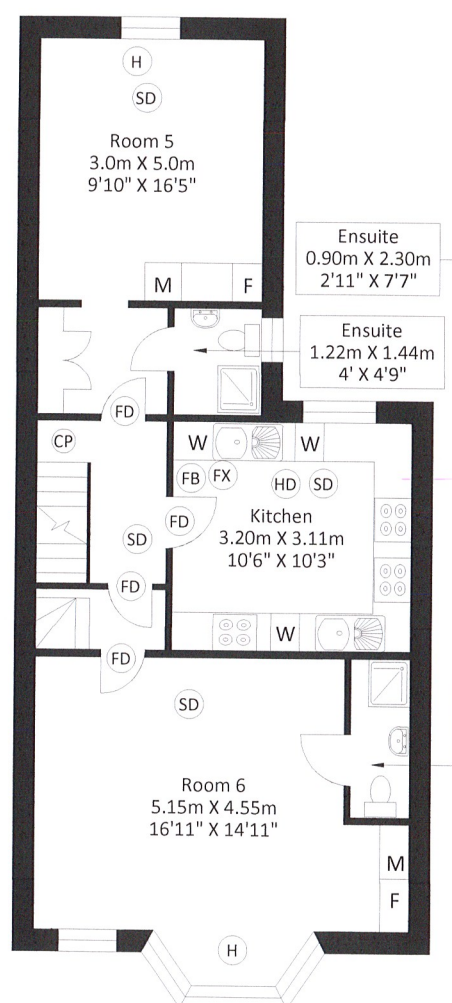


53 Cranbrook Park, London, N22 5PT

Note:

- | | | | |
|------|---------------------|------|--------------------|
| (FD) | = Fire Door | (F) | = Fridge Freezer |
| W | = Washing Dryer | (H) | = Heating |
| FX | = Fire Extinguisher | (FB) | = Fire Blanket |
| (EL) | = Emergency Light | (HD) | = Heat Detector |
| (CP) | = Call Point | FAP | = Fire Alarm Panel |
| (SD) | = Smoke Detector | E | = Electric Meter |
| (M) | = Microwave | | |

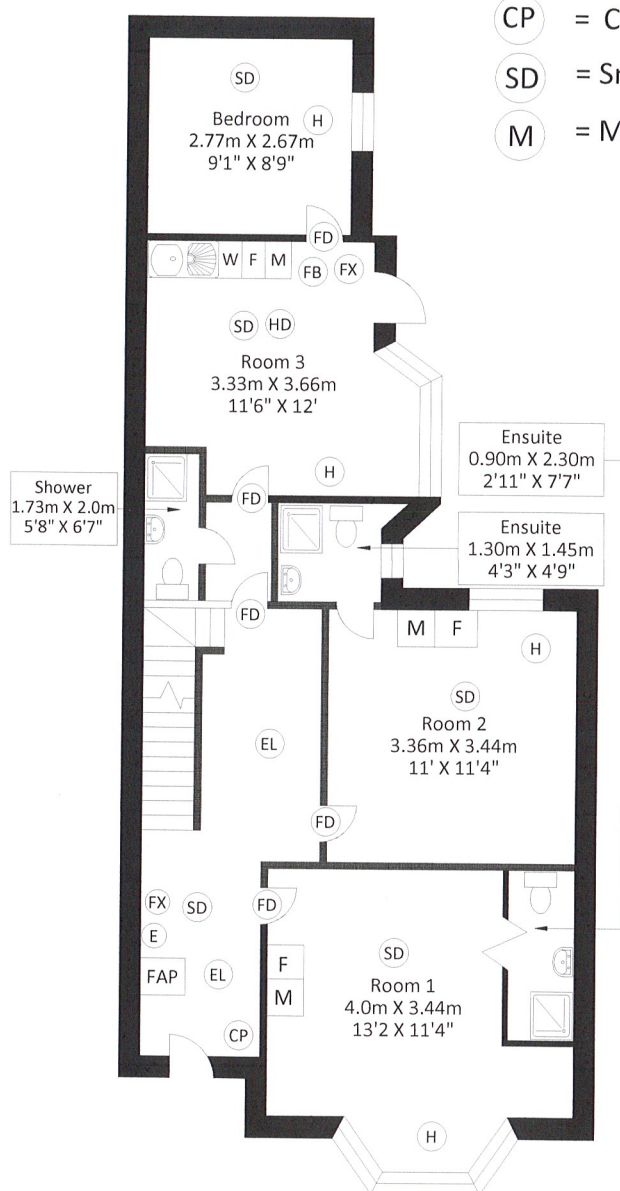

1:100 CM @ A4



SCALE: From the plan to be scaled, the above scale bar must measure correct, e.g. 5 Centimeters when printed

Page 1/2

FLOOR PLANS, LEASE PLANS, ALCOHOL LICENSE PLANS
EPC - ENERGY PERFORMANCE CERTIFICATES,
PROPERTY PHOTOGRAPHY, BROCHURES

Drawing title : 53 Cranbrook Park, London, N22 5PT

Scale : 1:100 CM @ A4


Copyright :

Date: 25-January-2024


53 Cranbrook Park, London, N22 5PT

Note:

- | | | | |
|------|---------------------|------|--------------------|
| (FD) | = Fire Door | (F) | = Fridge Freezer |
| W | = Washing Dryer | (H) | = Heating |
| FX | = Fire Extinguisher | (FB) | = Fire Blanket |
| (EL) | = Emergency Light | (HD) | = Heat Detector |
| (CP) | = Call Point | FAP | = Fire Alarm Panel |
| (SD) | = Smoke Detector | E | = Electric Meter |
| (M) | = Microwave | | |

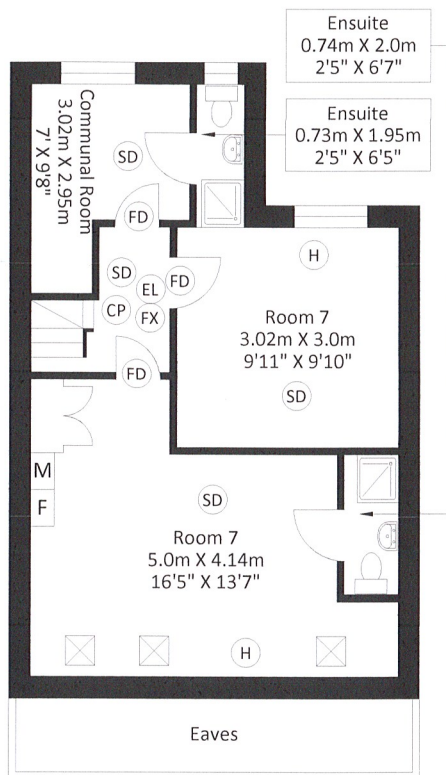

Second Floor Area
389.77 sq. ft
(36.21 sq.m)

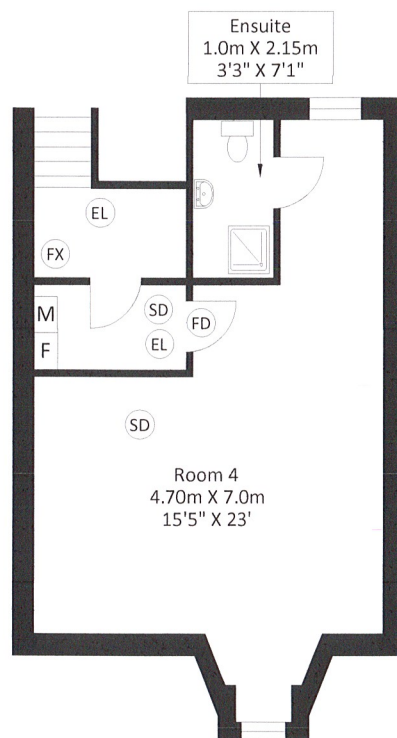

Basement Area
338.64 sq. ft
(31.46 sq.m)

1:100 CM @ A4



SCALE: From the plan to be scaled, the above scale bar must measure correct, e.g. 5 Centimeters when printed

Page 2/2

FLOOR PLANS, LEASE PLANS, ALCOHOL LICENSE PLANS
EPC - ENERGY PERFORMANCE CERTIFICATES,
PROPERTY PHOTOGRAPHY, BROCHURES

Drawing title : 53 Cranbrook Park, London, N22 5PT

Scale : 1:100 CM @ A4

Copyright :

Date: 25-January-2024