

LEGEND


	SINGLE GANG 13A UNSWITCHED SOCKET OUT SERVING AS NOTED		EVC VEHICLE CHARGING POINT		BULK HEAD LIGHT FITTING 'E' DENOTES EMERGENCY
	CLEANER'S SOCKET OUTLET		ELECTRIC CHARGING POINT FOR BIKES		LED LUMINAIRE
	TWO GANG 13A UNSWITCHED SOCKET OUTLET		MAG LOCK		LINEAR FLUORESCENT/ LED LUMINAIRE
	13A FUSED CONNECTION UNIT SERVING AS NOTED		INTERCOM MASTER STATION -'A' DENOTES AUDIO ONLY, -'A/V' DENOTES AUDIO VISUAL		WALL MOUNTED LIGHT - REFER TO LUMINAIRE SCHEDULE FOR DETAILS
	20A/32A FLEX OUTLET FRONTPLATE SERVING AS NOTED		REQUEST TO EXIT SWITCH		DENOTES EMERGENCY LIGHTING
	13A (UNLESS NOTED OTHERWISE) FUSED PERMANENT CONNECTION UNIT		BREAK GLASS / DOOR RELEASE		ONE WAY SWITCH (N DENOTES No. OF GANGS)
	ISOLATOR		COMBINED PROXIMITY READER AND KEYPAD		TWO WAY SWITCH (N DENOTES No. OF GANGS)
	DISTRIBUTION BOARD (DB)		FIRE ALARM BREAK GLASS CALL POINT (BGCP)		PRESENCE DETECTOR FOR LOCAL LIGHTING CIRCUIT (360°)
	PANEL BOARD (PB)		SMOKE DETECTOR (GENERAL)		
	UNDERFLOOR HEATING CONTROLS/WIRING CENTRE		COMBINED SMOKE DETECTOR/SOUNDER		
	BT OUTLET MASTER		COMBINED HEAT DETECTOR/SOUNDER		
	DATA OUTLET (RJ11)		FIREMAN'S SWITCH		
	DATA OUTLET (RJ45)		FIRE ALARM PANEL		

ABBREVIATIONS

B	BOILER	LL	LOW LEVEL
BAT	COMPLETE WITH BATTERY BACK UP	ML	MIRROR LIGHT
BS	BOOST SWITCH	N	NEON INDICATOR
C	COOKER	OV	OVEN
CH	COOKER HOOD	PL	PELMET LIGHTING
CM	COFFEE MACHINE	SC	STOP COCK
DW	DISH WASHER	TD	TUMBLE DRYER
EH	ELECTRIC HEATER	TR	TOWEL RAIL
EX	EXTRACT	UFHM	UNDERFLOOR HEATING MANIFOLD
FF	FRIDGE FREEZER	USB	UNIVERSAL SERIAL BUS
HL	HIGH LEVEL	WD	WARMING DRAWER
HWC	HOT WATER CYLINDER	WM	WASHING MACHINE
IA	INTRUDER ALARM	WT	WORKTOP LEVEL
IM	IMMERSION		

GENERAL NOTES

1. ALL DRAWINGS MUST BE READ IN CONJUNCTION WITH ALL OTHER RELEVANT ARCHITECTURAL AND STRUCTURAL ENGINEERS DRAWINGS / OR SPECIFICATIONS. ANY DISCREPANCY FOUND BETWEEN THESE DRAWINGS AND ANY OTHER ARCHITECTURAL AND STRUCTURAL ENGINEERS DETAILS DRAWINGS IS TO BE REPORTED IMMEDIATELY BEFORE ANY WORKS ARE CARRIED OUT.

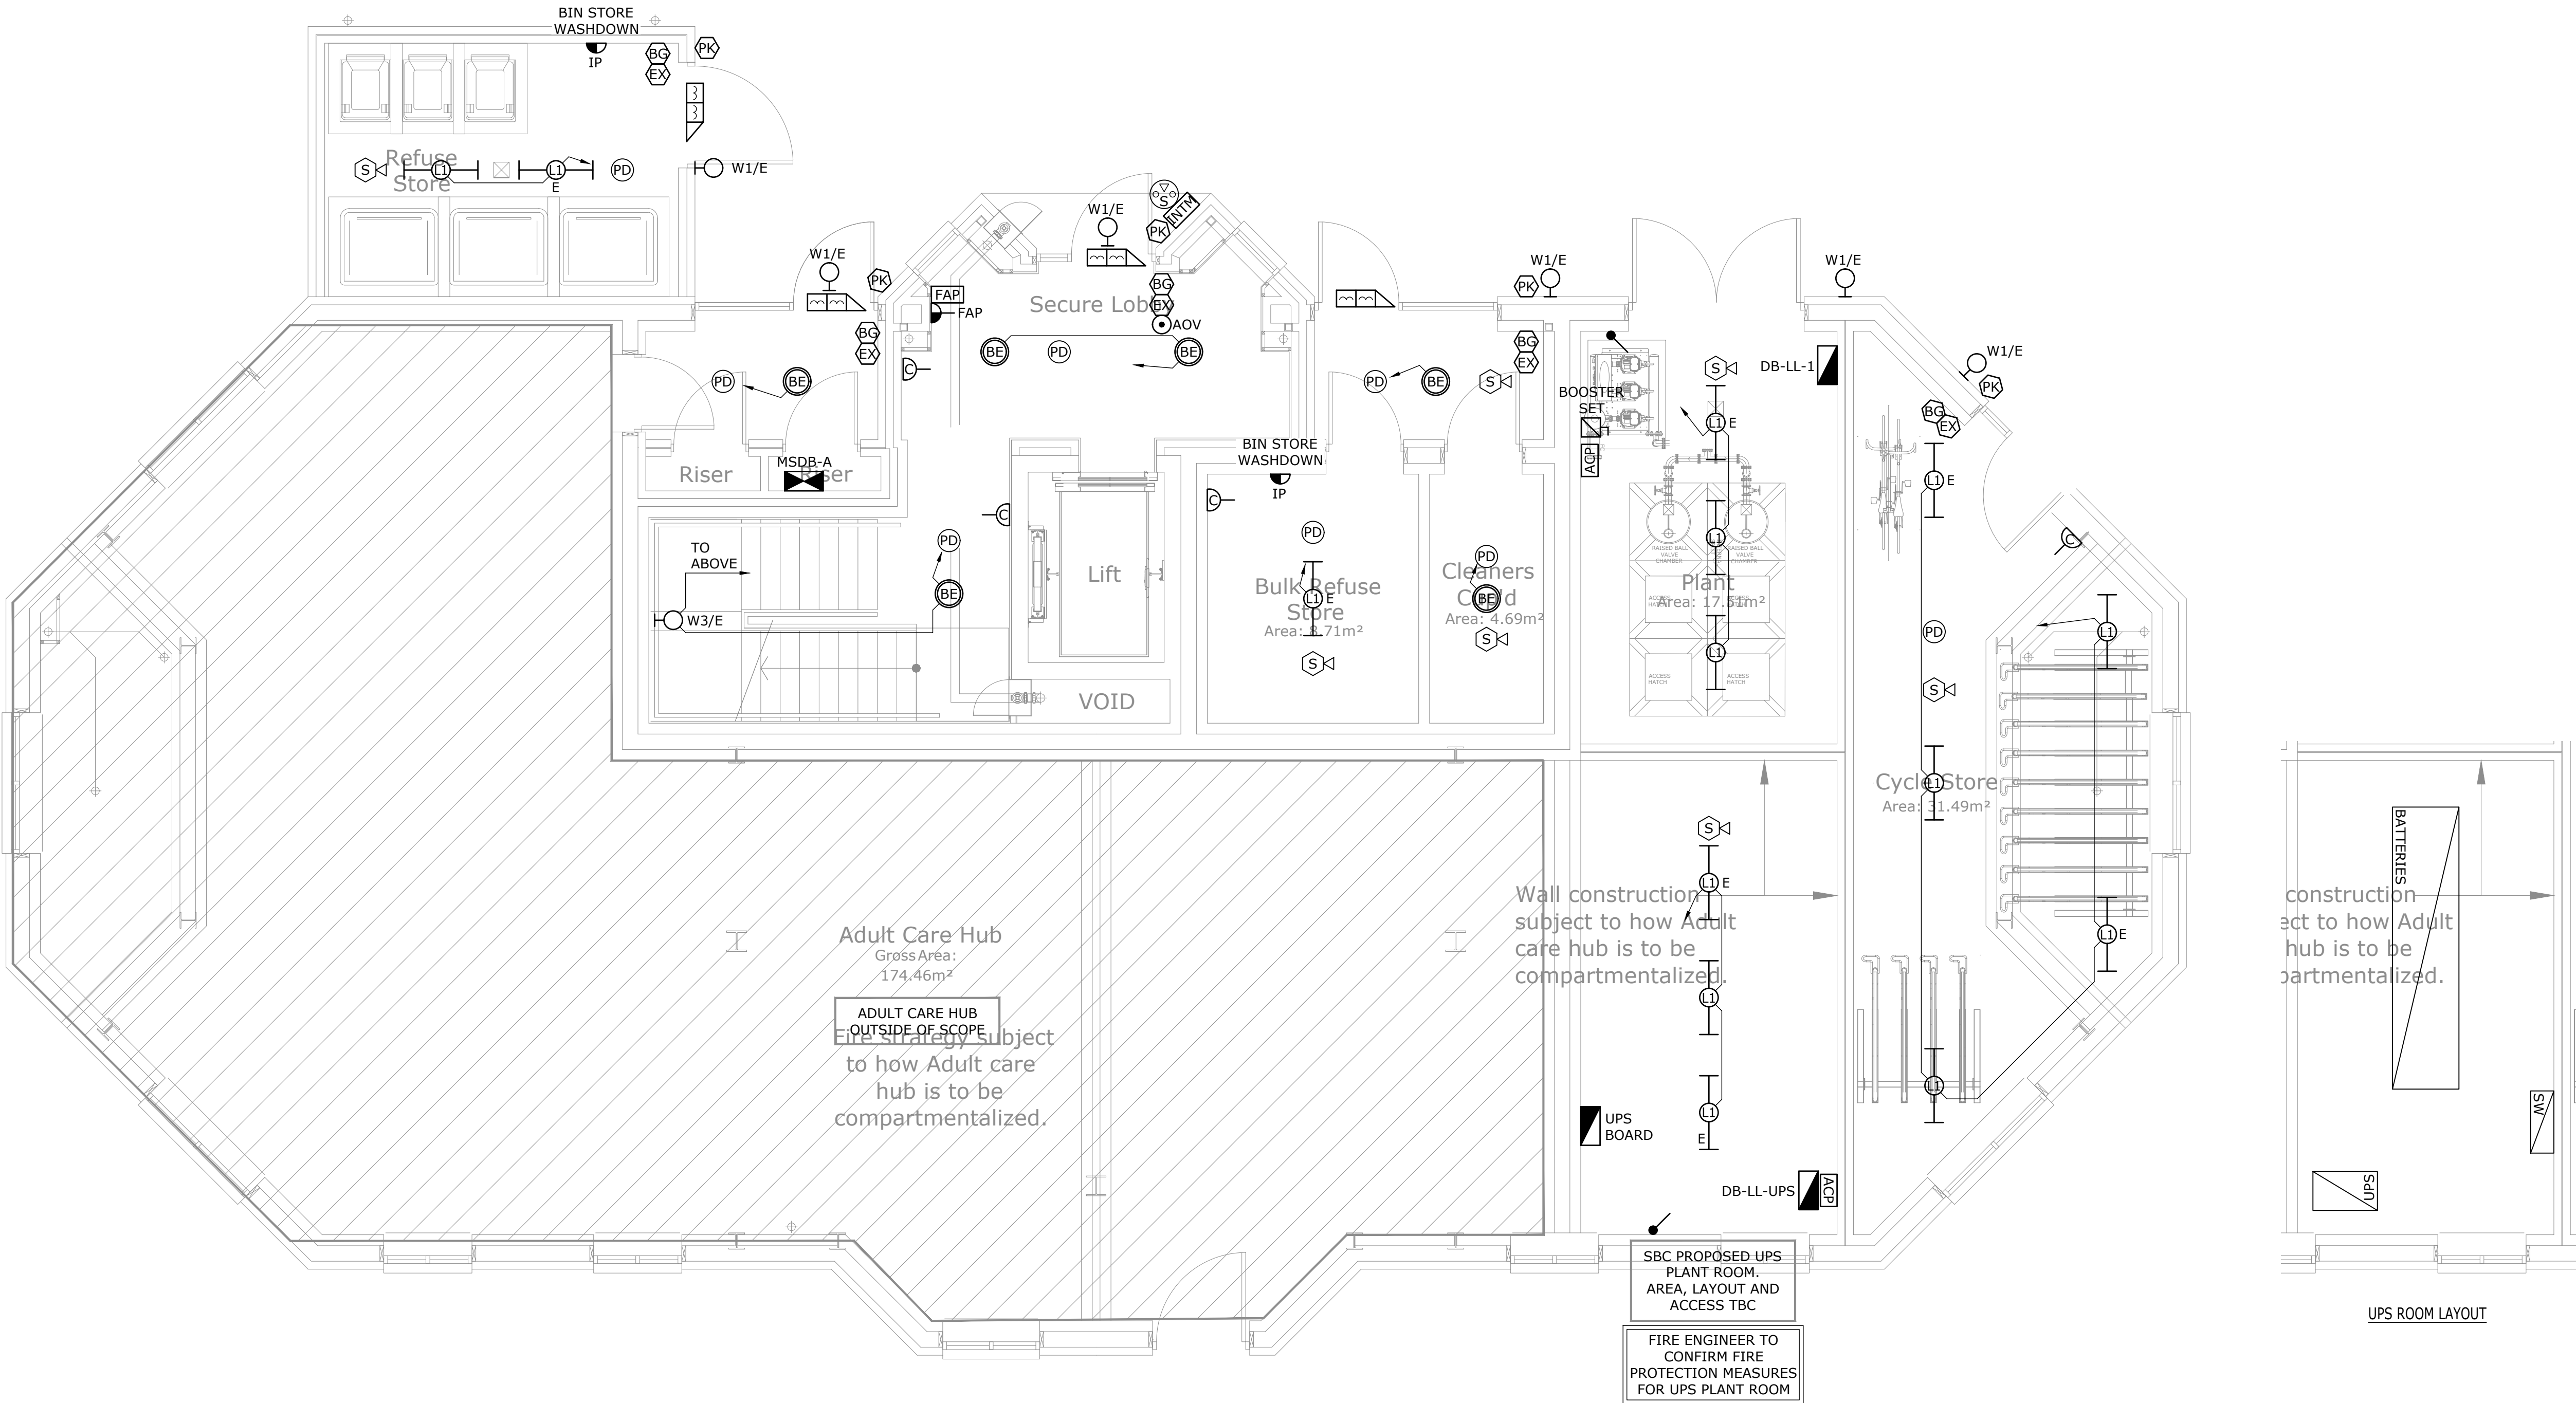

C2	06/03/24	SBC INSTRUCTED ADDITIONAL UPS
C1	26/01/24	CONSTRUCTION ISSUE
T2	23/01/24	TENDER ISSUE
T1	25/09/23	TENDER ISSUE
P1	26/05/23	PRELIMINARY ISSUE

Rev	Date	Description
-----	------	-------------



Target Technical Consulting Ltd
136-140 Old Shoreham Road,
Hove,
East Sussex
BN3 7BD,
Tel: 01273 921425

Client



Project

KERSWELL CLOSE

Drawing Title

BLOCK A
GROUND FLOOR
ELECTRICAL SERVICES LAYOUT

Scale	Date	Designed	Checked
1:50 @ A1	APR 2023	CS	CM
Drawing No			Revision
23144-A-E-100			C2