

LEGEND

-  SINGLE GANG 13A UNSWITCHED SOCKET OUT SERVING AS NOTED
-  CLEANER'S SOCKET OUTLET
-  TWO GANG 13A UNSWITCHED SOCKET OUTLET
-  20A/32A FLEX OUTLET FRONTPLATE SERVING AS NOTED
-  13A (UNLESS NOTED OTHERWISE) FUSED PERMANENT CONNECTION UNIT
-  ISOLATOR
-  DISTRIBUTION BOARD (DB)
-  PANEL BOARD (PB)
-  UNDERFLOOR HEATING CONTROLS/WIRING CENTRE
-  BT OUTLET MASTER
-  RJ11 DATA OUTLET (RJ11)
-  RJ45 DATA OUTLET (RJ45)

-  EVC VEHICLE CHARGING POINT
-  ECP ELECTRIC CHARGING POINT FOR BIKES
-  MAG LOCK
-  INTERCOM MASTER STATION
- 'A' DENOTES AUDIO ONLY,
- 'A/V' DENOTES AUDIO VISUAL
-  REQUEST TO EXIT SWITCH
-  BREAK GLASS / DOOR RELEASE
-  COMBINED PROXIMITY READER AND KEYPAD
-  FIRE ALARM BREAK GLASS CALL POINT (BGCP)
-  SMOKE DETECTOR (GENERAL)
-  COMBINED SMOKE DETECTOR/SOUNDER
-  COMBINED HEAT DETECTOR/SOUNDER
-  FIREMAN'S SWITCH
-  FIRE ALARM PANEL

-  BULK HEAD LIGHT FITTING
'E' DENOTES EMERGENCY
-  LED LUMINAIRE
-  LINEAR FLUORESCENT/ LED LUMINAIRE
-  WALL MOUNTED LIGHT - REFER TO LUMINAIRE SCHEDULE FOR DETAILS
-  E DENOTES EMERGENCY LIGHTING
-  ONE WAY SWITCH (N DENOTES No. OF GANGS)
-  TWO WAY SWITCH (N DENOTES No. OF GANGS)
-  PRESENCE DETECTOR FOR LOCAL LIGHTING CIRCUIT (360°)

ABBREVIATIONS

- B

BOILER
- BAT

COMPLETE WITH BATTERY BACK UP
- BS

BOOST SWITCH
- C

COOKER
- CH

COOKER HOOD
- CM

COFFEE MACHINE
- DW

DISH WASHER
- EH

ELECTRIC HEATER
- EX

EXTRACT
- FF

FRIDGE FREEZER
- HL

HIGH LEVEL
- HWC

HOT WATER CYLINDER
- IA

INTRUDER ALARM
- IM

IMMERSION
- LL

LOW LEVEL
- ML

MIRROR LIGHT
- N

NEON INDICATOR
- OV

OVEN
- PL

PELMET LIGHTING
- SC

STOP COCK
- TD

TUMBLE DRYER
- TR

TOWEL RAIL
- UFHM

UNDERFLOOR HEATING MANIFOLD
- USB

UNIVERSAL SERIAL BUS
- WD


WARMING DRAWER
- WM

WASHING MACHINE
- WT

WORKTOP LEVEL

GENERAL NOTES

1. ALL DRAWINGS MUST BE READ IN CONJUNCTION WITH ALL OTHER RELEVANT ARCHITECTURAL AND STRUCTURAL ENGINEERS DRAWINGS / OR SPECIFICATIONS. ANY DISCREPANCY FOUND BETWEEN THESE DRAWINGS AND ANY OTHER ARCHITECTURAL AND STRUCTURAL ENGINEERS DETAILS DRAWINGS IS TO BE REPORTED IMMEDIATELY BEFORE ANY WORKS ARE CARRIED OUT.

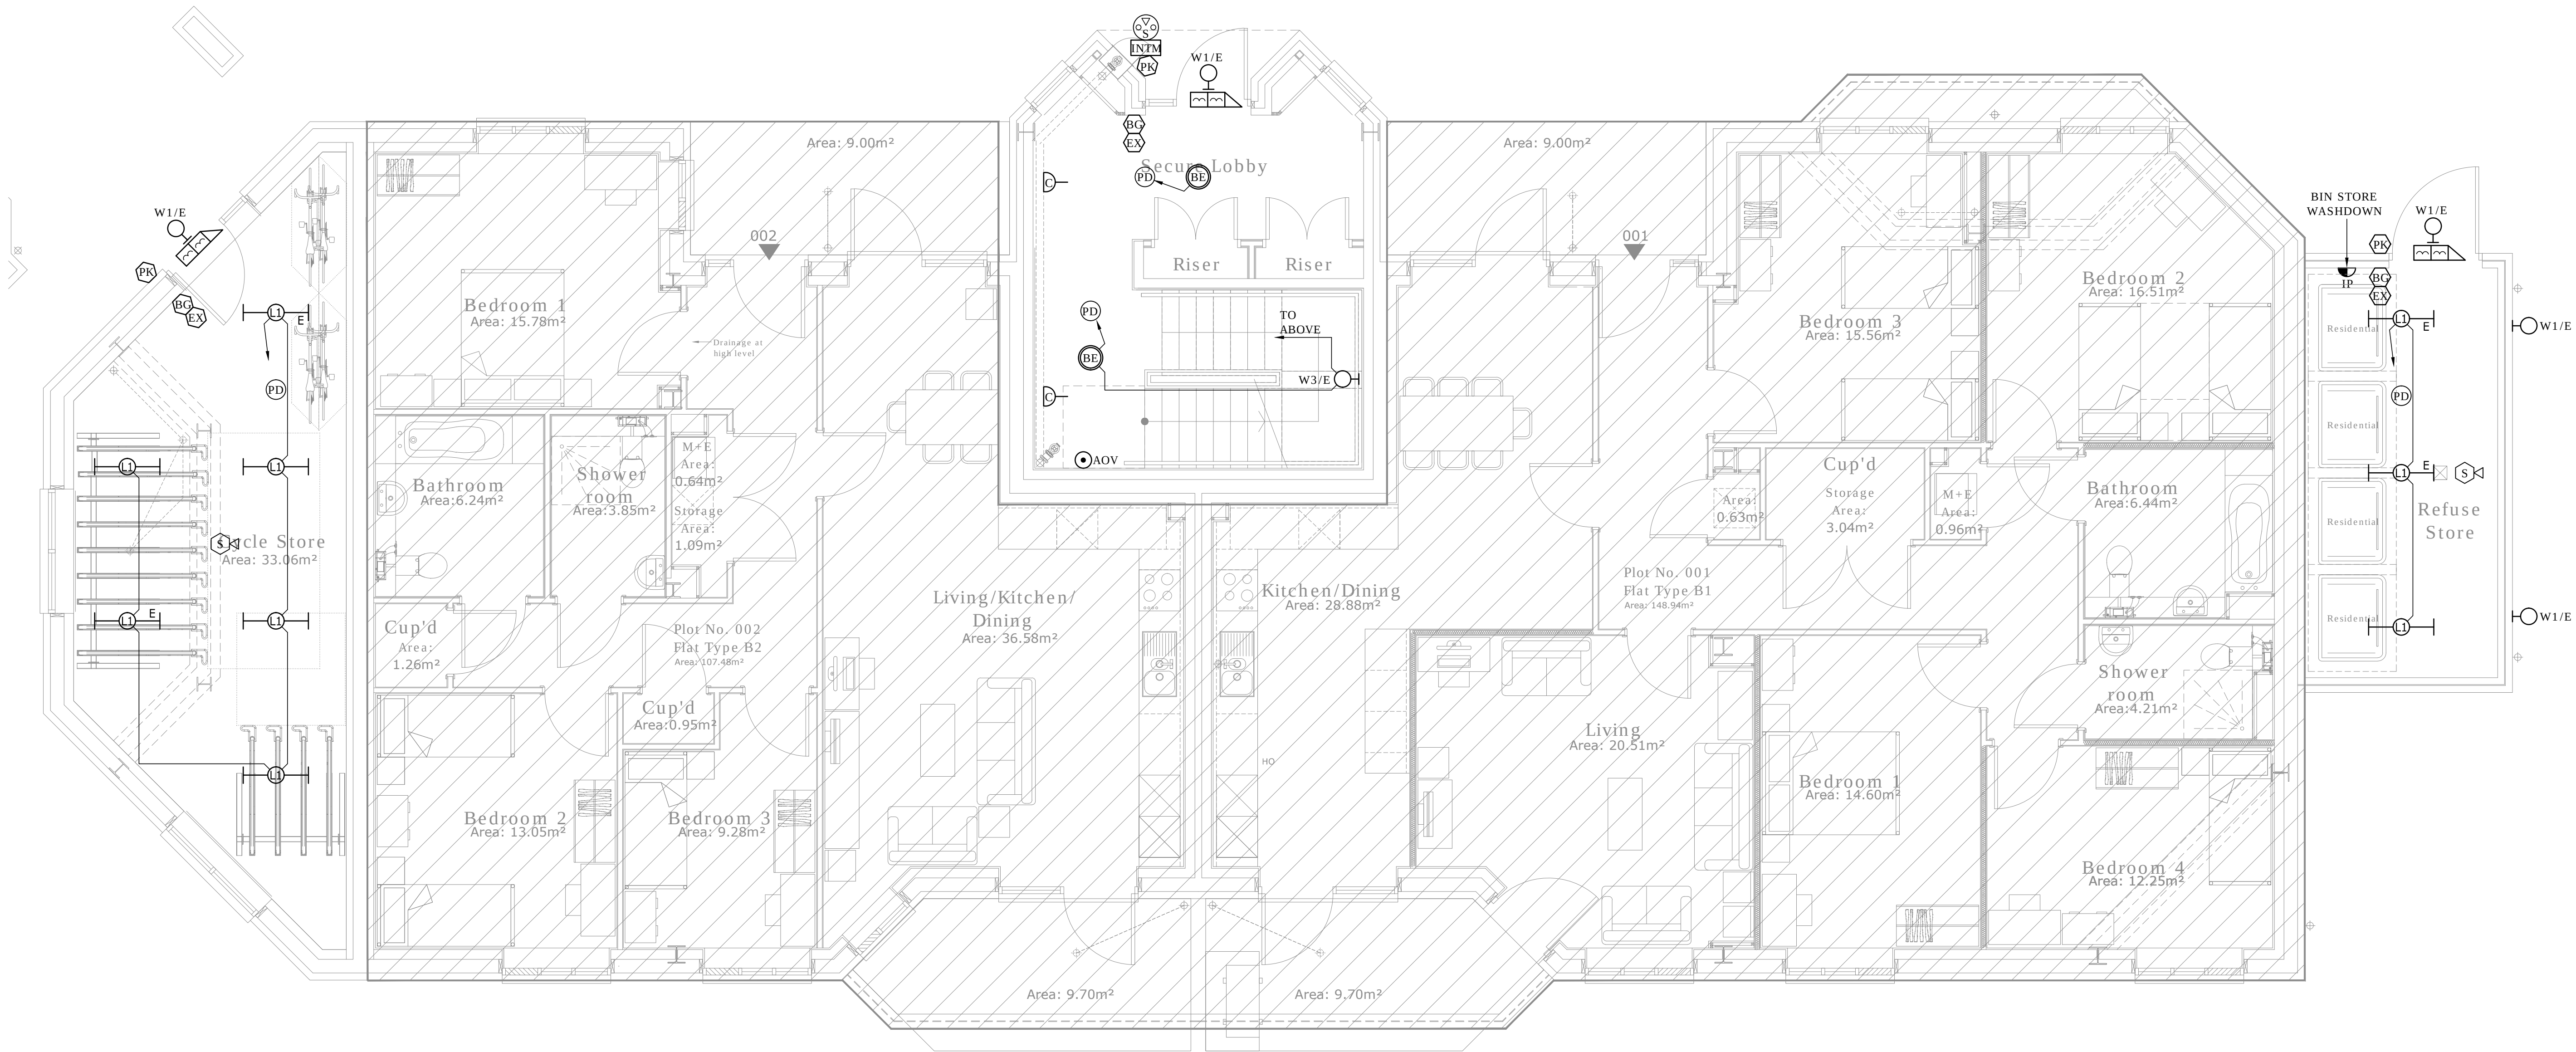

C126/01/24CONSTRUCTION ISSUE T223/01/24TENDER ISSUE T125/09/23TENDER ISSUE P126/05/23PRELIMINARY ISSUE Rev Date Description TTC TARGET TECHNICAL CONSULTING Target Technical Consulting Ltd 136-140 Old Shoreham Road, Hove, East Sussex BN3 7BD, Tel: 01273 921425			Client		Drawing Title			
			SBC SELSDON Building Contractors LIMITED		BLOCK B GROUND FLOOR ELECTRICAL SERVICES LAYOUT			
			Project		Scale	Date	Designed	Checked
			KERSWELL CLOSE		1:50 @ A1	APR 2023	CS	CM
			Drawing No					Revision
23144-B-E-100					C1			