


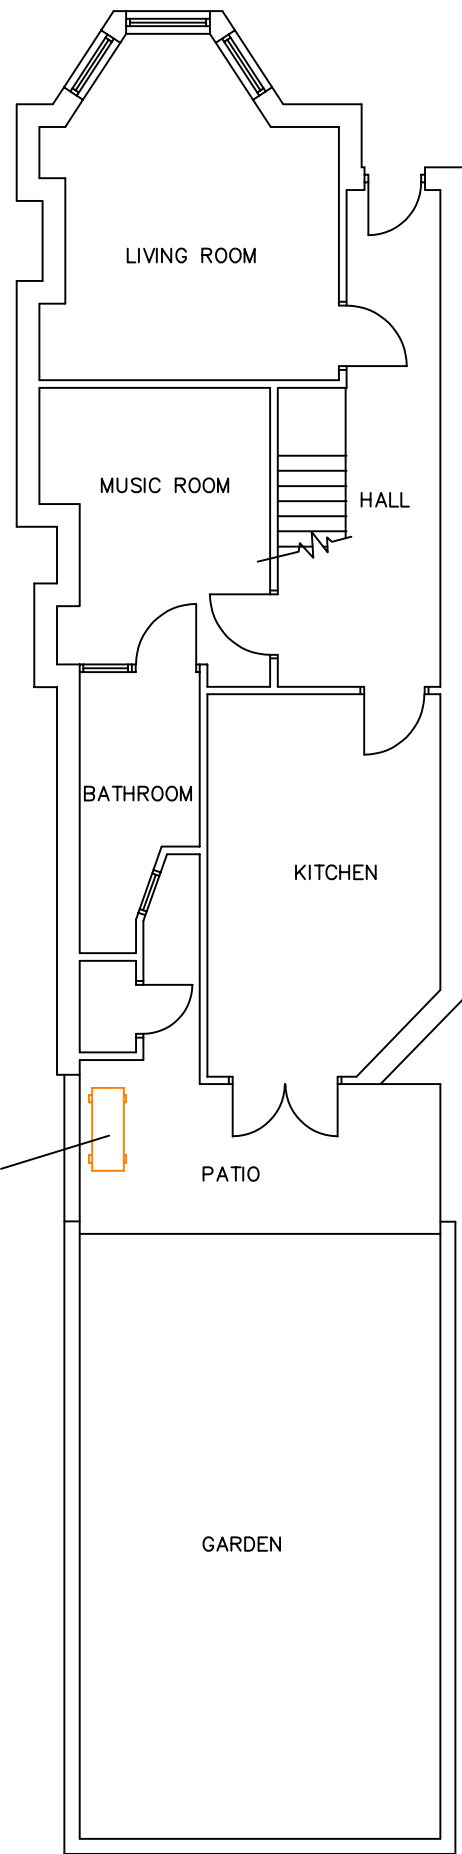


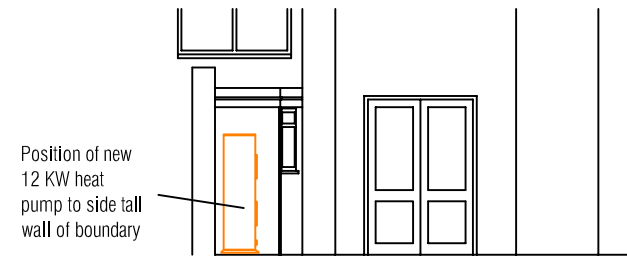


PROPOSED GROUND FLOOR PLAN 1:100

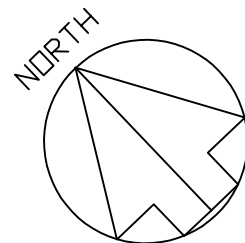

PROPOSED REAR ELEVATION 1:100

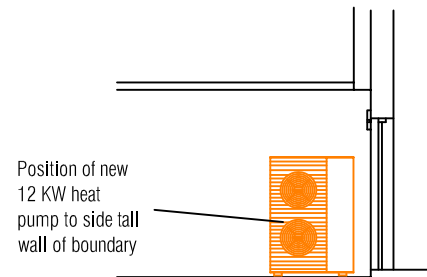

PROPOSED REAR SIDE ELEVATION 1:100

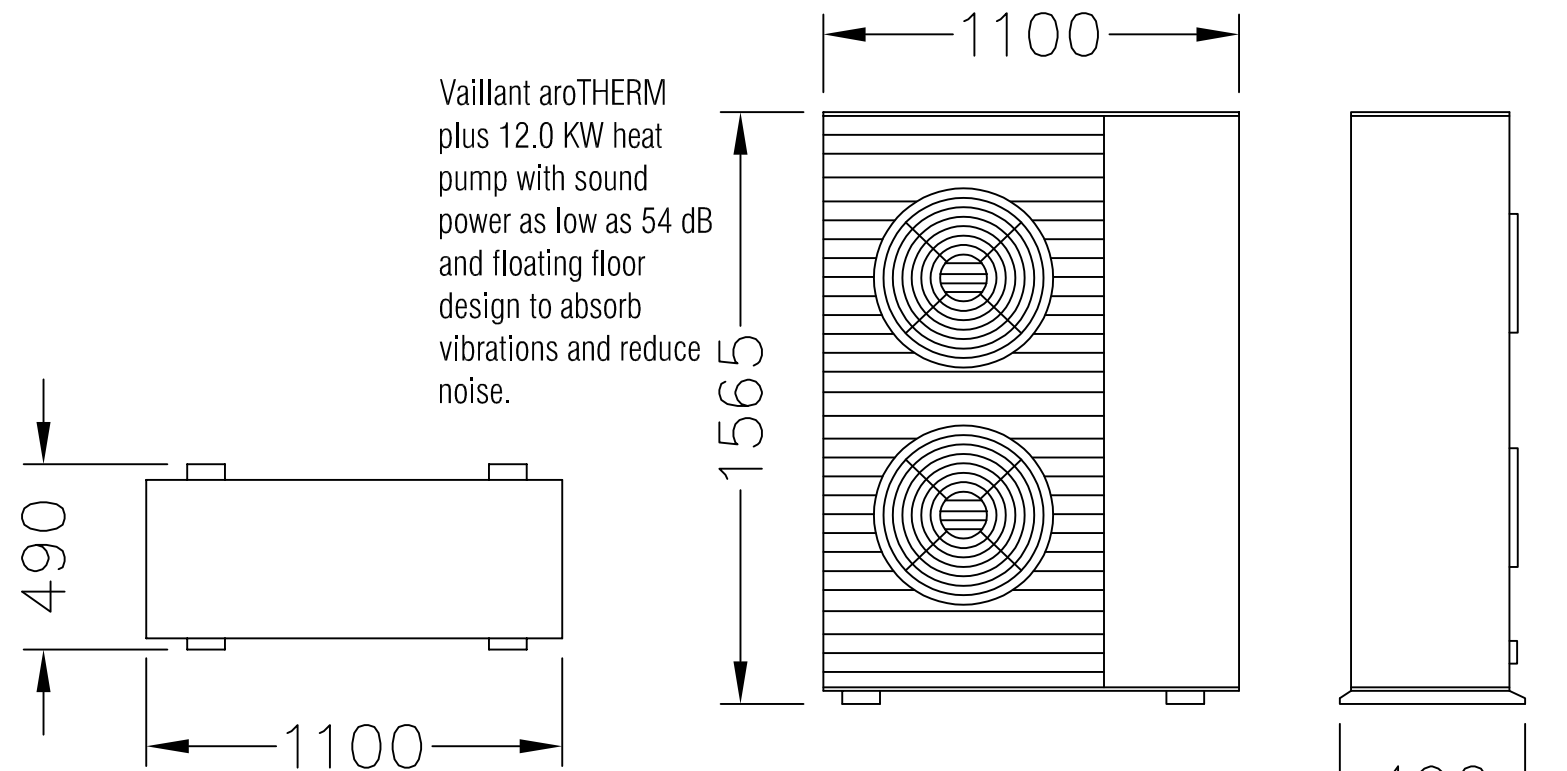

HEAT PUMP 12 KW DIMENSIONS

NOTES:


This drawing is not a working drawing, and is only for the purpose of the following:-

A- Planning Submission

The main contractor is responsible for Informing the lead designer of any discrepancy on, or between, this drawing and any other relevant document.

Boundaries, angles, and dimensions are to be checked by the main contractor prior to work commencing.

Written dimensions only to be used from this drawing. If in doubt consult the lead designer for clarification.

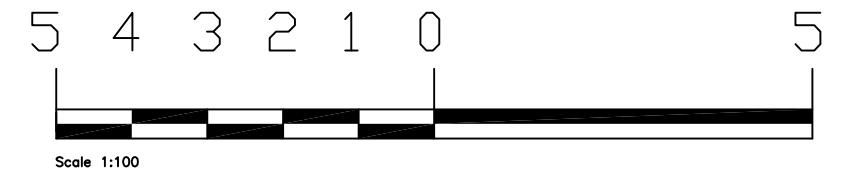

HEAT PUMP IMAGE

STUDIO CHARRETTE

A: The Clubhouse, 50 Grosvenor Hill, London, W1K 3QT
W: www.studiocharrette.co.uk

Client

Dianne Sandler

Project Title

6 Rathcoole Avenue,
London N8 9NA

Drawing Title
Proposed Air source heat pump installation

Proposed plan and elevation

Drawing No. SC / 23 / 216 - 201		Rev	
Scale 1:50 @ A3	Date - March 2024	Planning	
		Building Control	
		Client	
		Sketch	
		Information	
		Created By A Mc	
Check By			

This drawing and the copyright, design rights and all other intellectual property rights in it belong to Studio Charrette Ltd. No license or assignment of any such rights is granted hereunder. This drawing is not to be copied or divulged to a third party without written permission.