


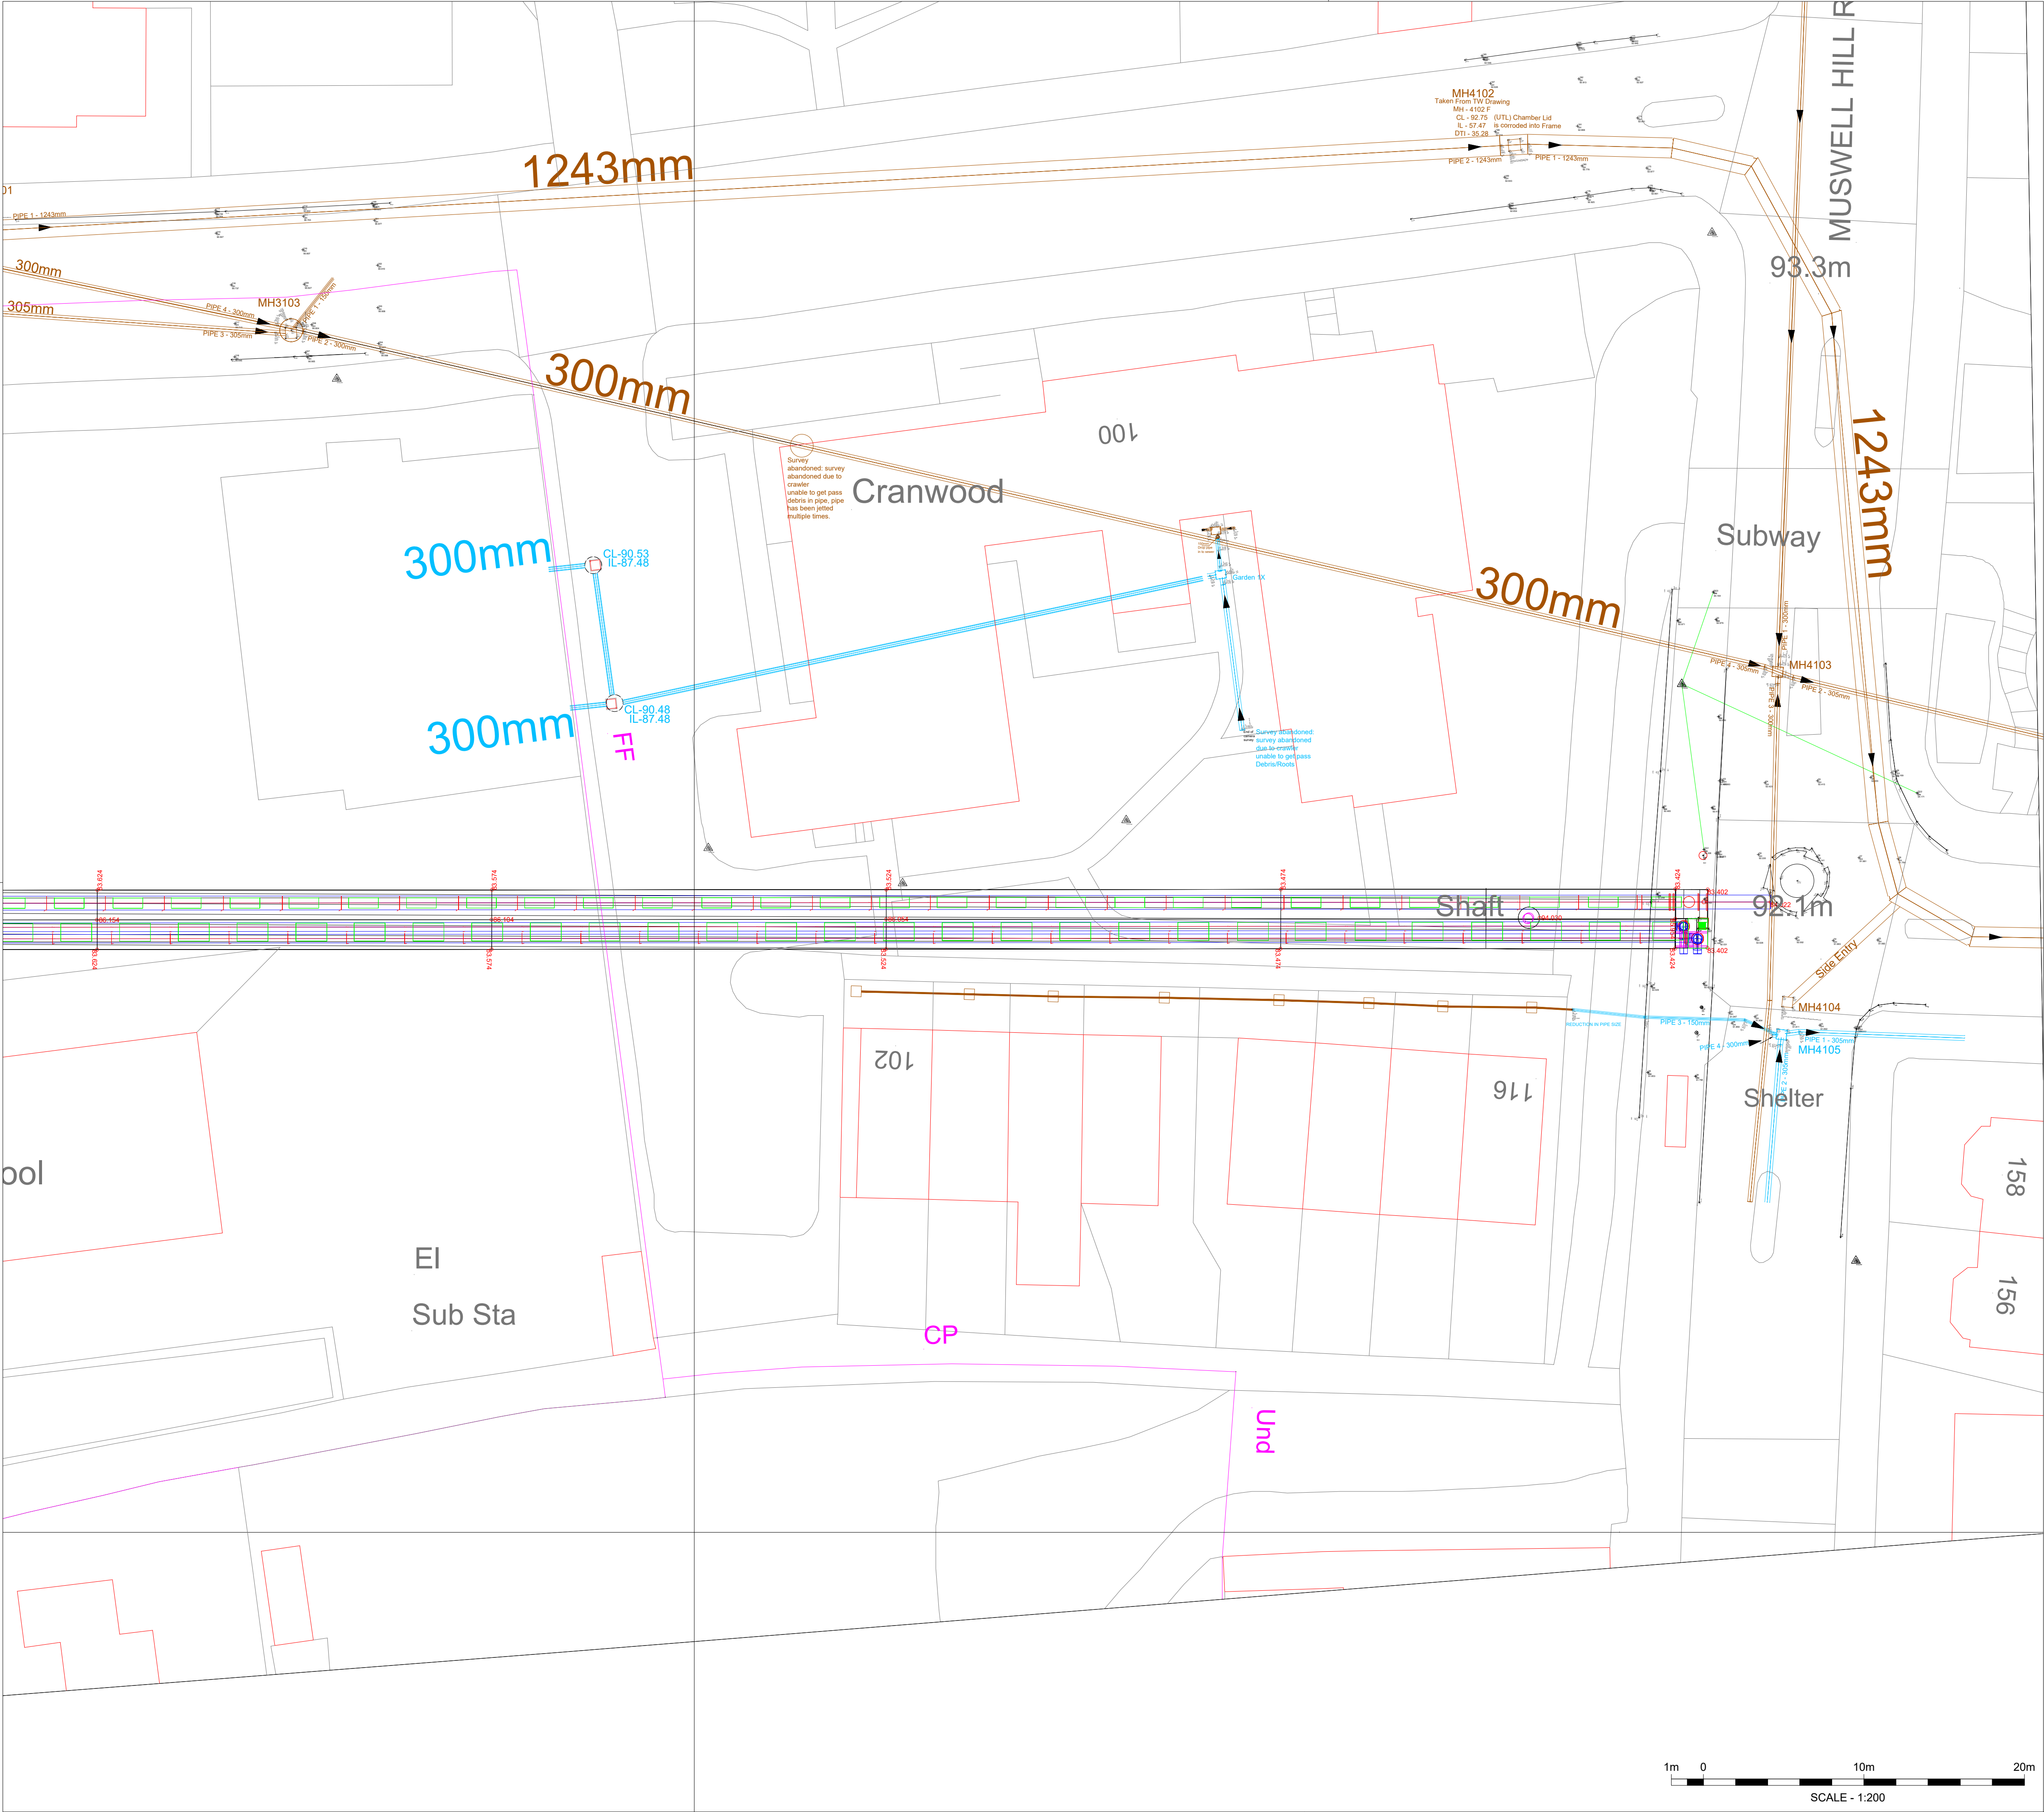

COMPUTER AIDED DRAWING - AVOID MANUAL MODIFICATION

THIS DRAWING MUST NOT BE SCALED,
ALL DIMENSIONS TO BE CHECKED ON SITE.

DISCLAIMER

The information shown within is given without obligation, or warranty, the accuracy thereof cannot be guaranteed. No liability of any kind whatsoever is accepted by Cable Tracing Services Limited its operatives for any error or omission.

Safe digging practices, in accordance with HS(G)47 must be used to verify and establish the actual position of the statutory undertaker's apparatus on site before any mechanical plant is used. It is your responsibility to ensure that this information is provided to all persons either direct labour or contractors. Any error found should be reported immediately to the management before any works are to be carried out.

Notes

This 3D Model has been drawn from point cloud data taken from the inside surfaces of the sewer structures.

ALL MEASUREMENTS ARE APPROXIMATE AND SHOULD BE VERIFIED ON SITE BY FOLLOWING THE SAFE DIGGING PRACTICES SET OUT IN THE HSG47 GUIDE.

COORDINATE SYSTEM SETTINGS:

SYSTEM - UNITED KINGDOM ZONE - OS NATIONALGRID(OSTN02)

DATUM - ORDNANCE SURVEY GEOID MODEL - (OSGM02)

COORDINATE ORDER - EAST FIRST - NORTH LAST

REFERENCE DRAWINGS.

DRAWING No	TITLE


Project Title:

Cranwood House

Client:

McAllister Group

Discipline:	Scale:	Project Phase:	
Topographical Survey & Laser Scanning	1:200@ A1	Survey Information	
Drawing Originator:	Drawn By:	Approval By:	
Cable Tracing Services Limited	DMB	JMB	
Drawing No:	Revision:	Drawn Date:	Check Date:
CTS-MC 0129 20-21(1)	B	15-12-20	17-06-21

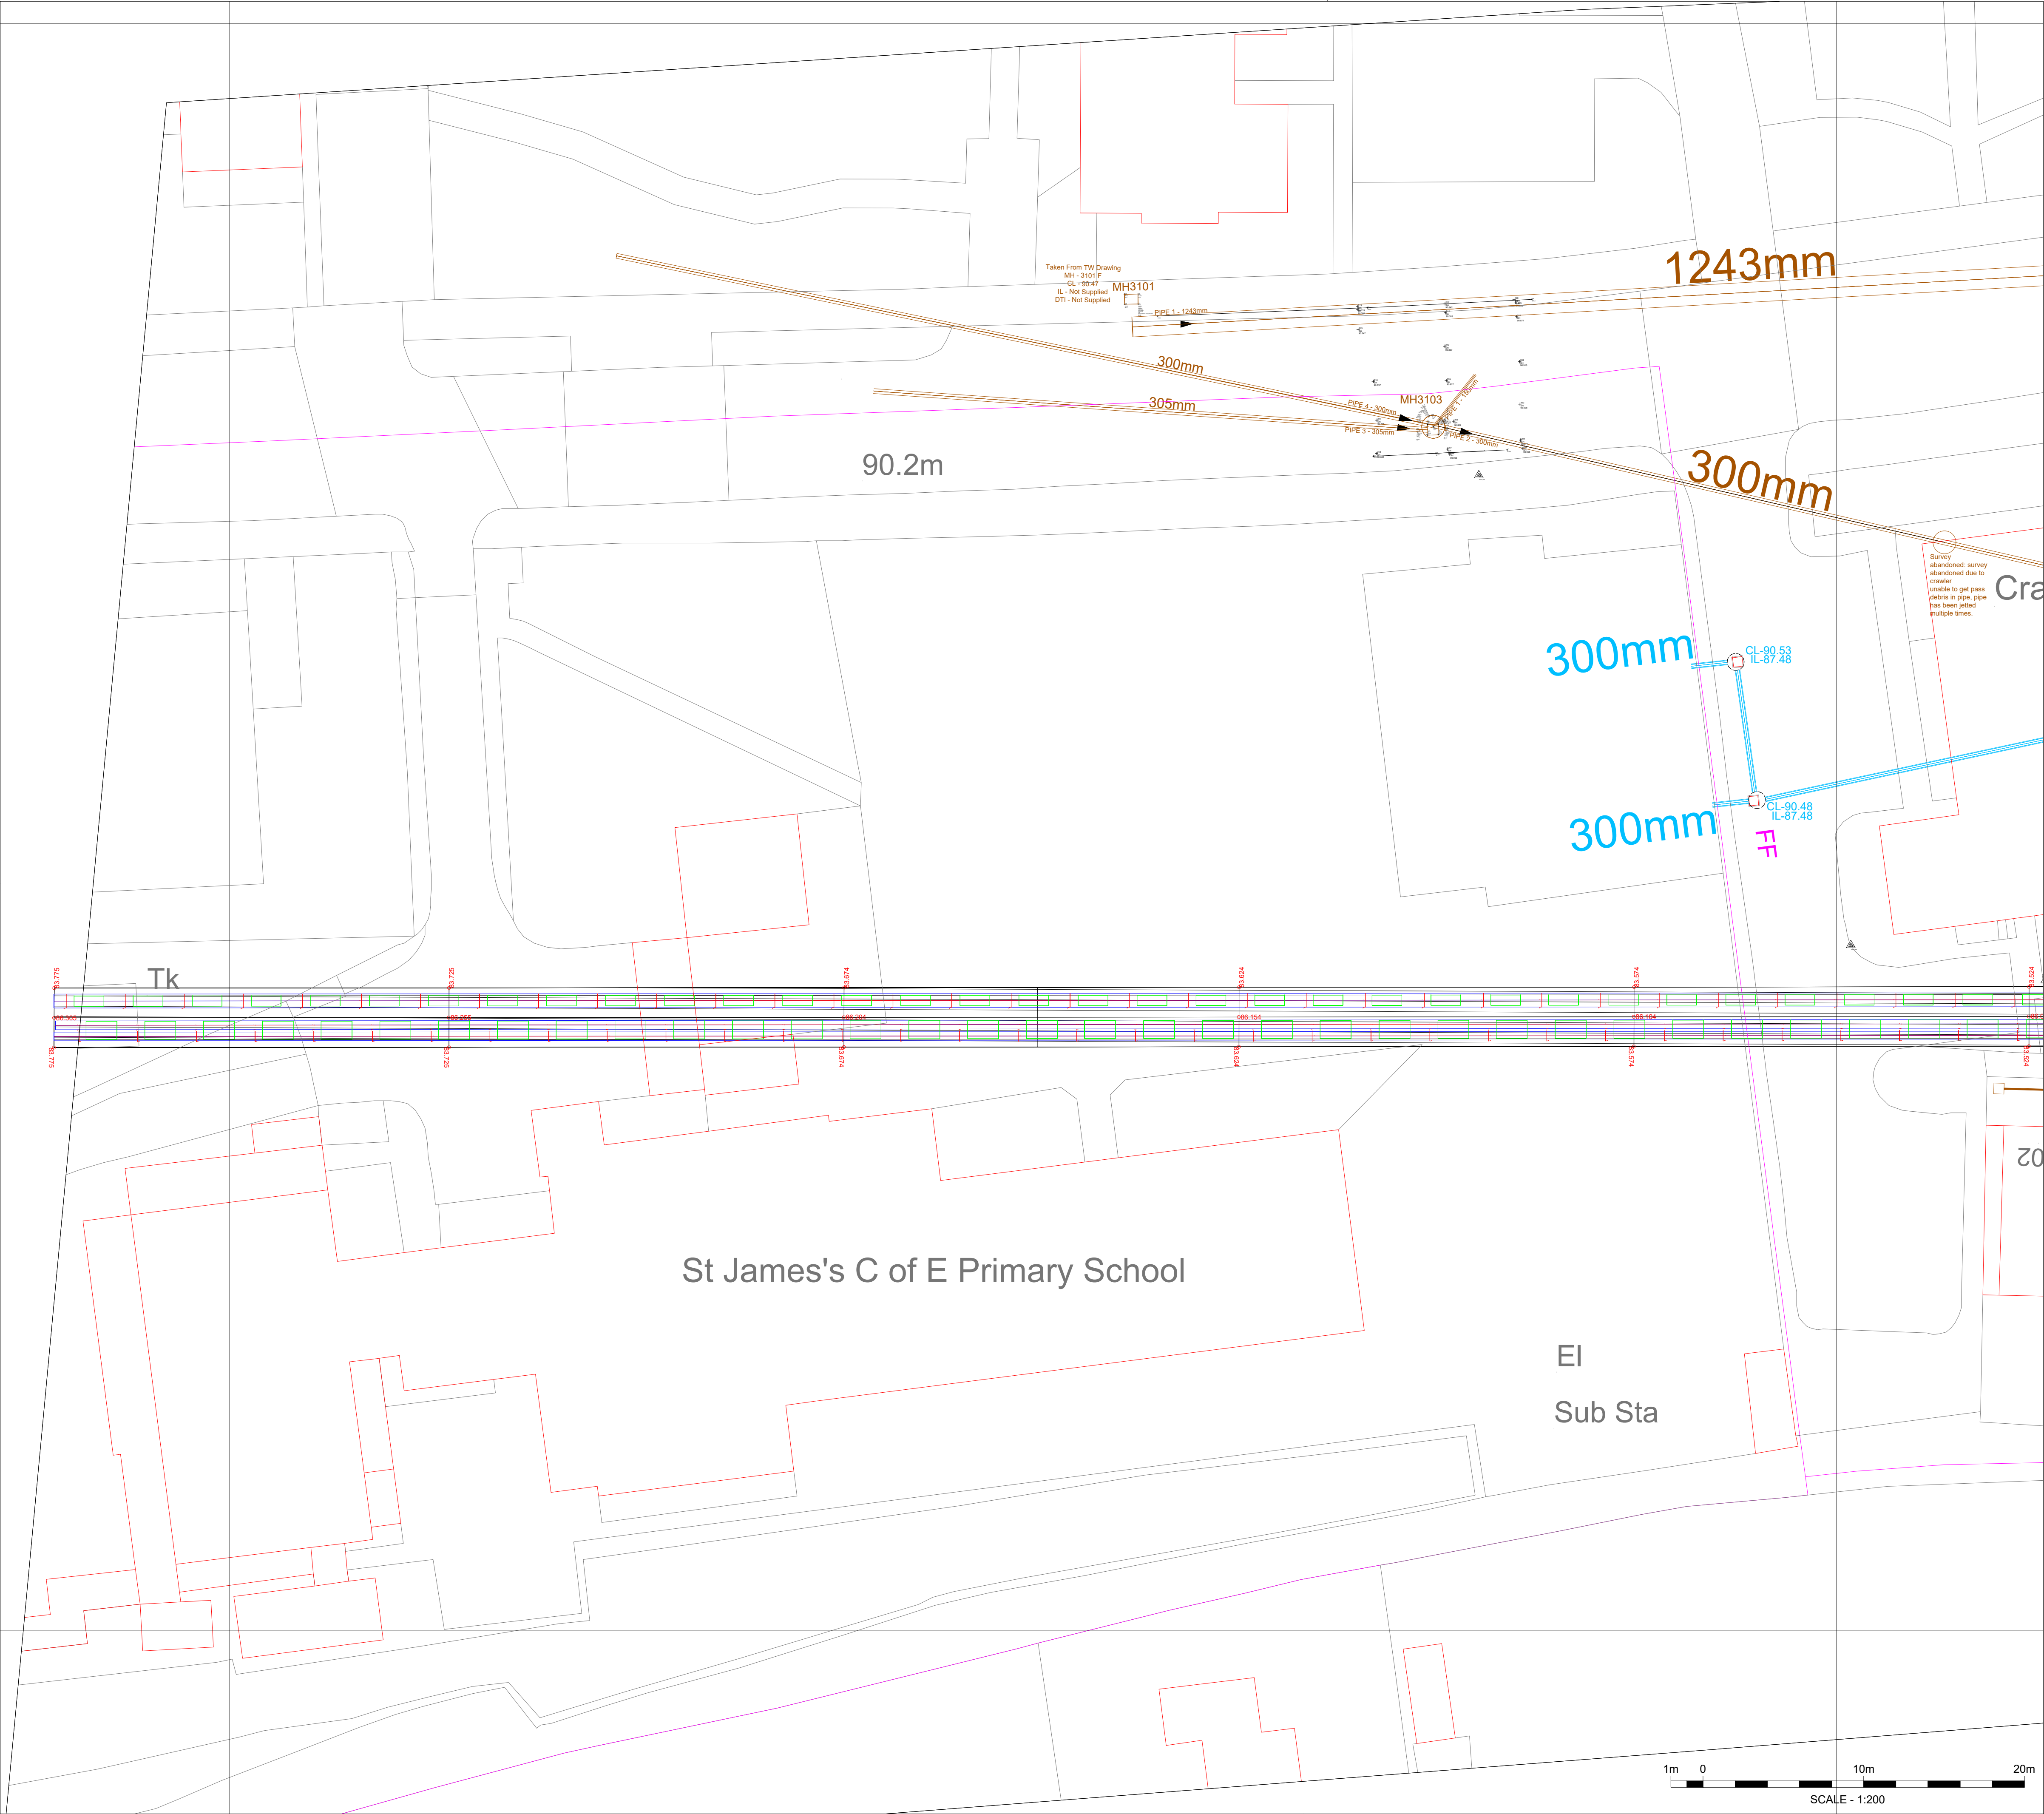

COMPUTER AIDED DRAWING - AVOID MANUAL MODIFICATION

THIS DRAWING MUST NOT BE SCALED,
ALL DIMENSIONS TO BE CHECKED ON SITE.


DISCLAIMER


The information shown within is given without obligation, or warranty, the accuracy thereof cannot be guaranteed. No liability of any kind whatsoever is accepted by Cable Tracing Services Limited its operatives for any error or omission.

Safe digging practices, in accordance with HS(G)47 must be used to verify and establish the actual position of the statutory undertaker's apparatus on site before any mechanical plant is used. It is your responsibility to ensure that this information is provided to all persons either direct labour or contractors. Any error found should be reported immediately to the management before any works are to be carried out.

Notes

This 3D Model has been drawn from point cloud data taken from the inside surfaces of the sewer structures.

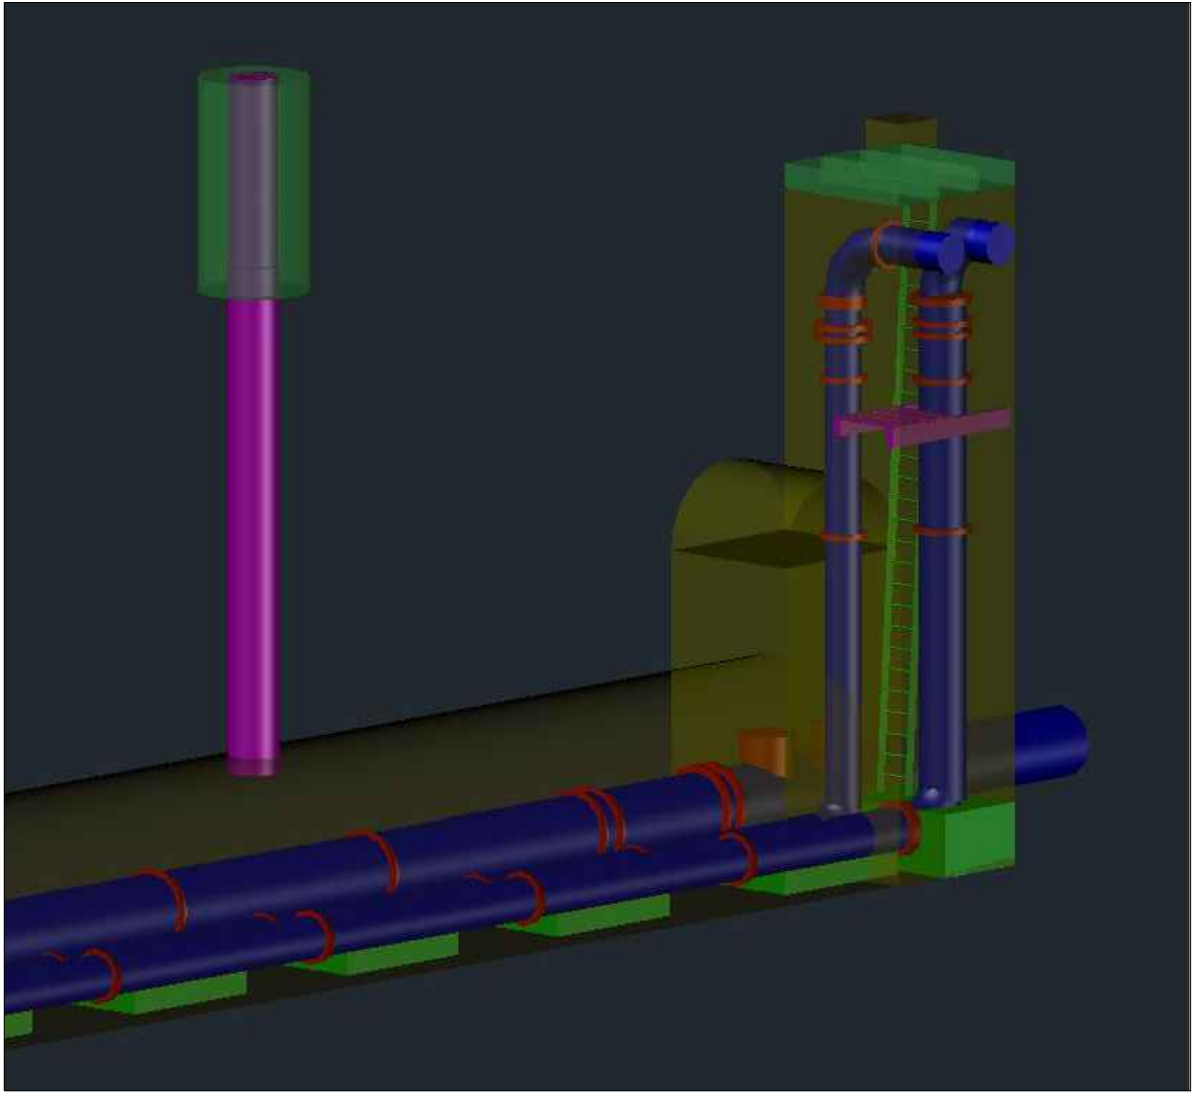

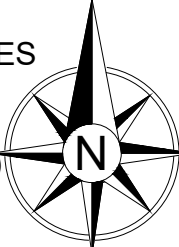ALL MEASUREMENTS ARE APPROXIMATE AND SHOULD BE VERIFIED ON SITE BY FOLLOWING THE SAFE DIGGING PRACTICES SET OUT IN THE HSG47 GUIDE. COORDINATE SYSTEM SETTINGS: SYSTEM - UNITED KINGDOM ZONE - OS NATIONALGRID(OSTN02) DATUM - ORDNANCE SURVEY GEOID MODEL - (OSGM02) COORDINATE ORDER - EAST FIRST - NORTH LAST REFERENCE DRAWINGS.			
DRAWING No		TITLE	
Project Title:			
Client:			
Discipline:		Scale:	Project Phase:
Topographical Survey & Laser Scanning		1:200@ A1	Survey Information
Drawing Originator:		Drawn By:	Approval By:
Cable Tracing Services Limited		DMB	JMB
Drawing No:		Revision:	Check Date:
CTS-MC 0129 20-21(2)		B	15-12-20 17-06-21



COMPUTER AIDED DRAWING - AVOID MANUAL MODIFICATION


THIS DRAWING MUST NOT BE SCALED,
ALL DIMENSIONS TO BE CHECKED ON SITE.

DISCLAIMER
The information shown within is given without obligation, or warranty, the accuracy thereof cannot be guaranteed. No liability of any kind whatsoever is accepted by Cable Tracing Services Limited its operatives for any error or omission.
Safe digging practices, in accordance with HS(G)47 must be used to verify and establish the actual position of the statutory undertaker's apparatus on site before any mechanical plant is used. It is your responsibility to ensure that this information is provided to all persons either direct labour or contractors. Any error found should be reported immediately to the management before any works are to be carried out.

Notes

This 3D Model has been drawn from point cloud data taken from the inside surfaces of the sewer structures.

ALL MEASUREMENTS ARE APPROXIMATE AND SHOULD BE VERIFIED ON SITE BY FOLLOWING THE SAFE DIGGING PRACTICES SET OUT IN THE HSG47 GUIDE. COORDINATE SYSTEM SETTINGS: SYSTEM - UNITED KINGDOM ZONE - OS NATIONALGRID(OSTN02) DATUM - ORDNANCE SURVEY GEOID MODEL - (OSGM02) COORDINATE ORDER - EAST FIRST - NORTH LAST REFERENCE DRAWINGS.			
DRAWING No		TITLE	
Project Title:			
Cranwood House			
Client:			
McAllister Group			
Discipline: Topographical Survey & Laser Scanning		Scale: NTS	Project Phase: Survey Information
Drawing Originator: Cable Tracing Services Limited		Drawn By: DMB	Approval By: JMB
Drawing No: CTS-MC 0129 20-21(3)	Revision: B	Drawn Date: 15-12-20	Check Date: 17-06-21

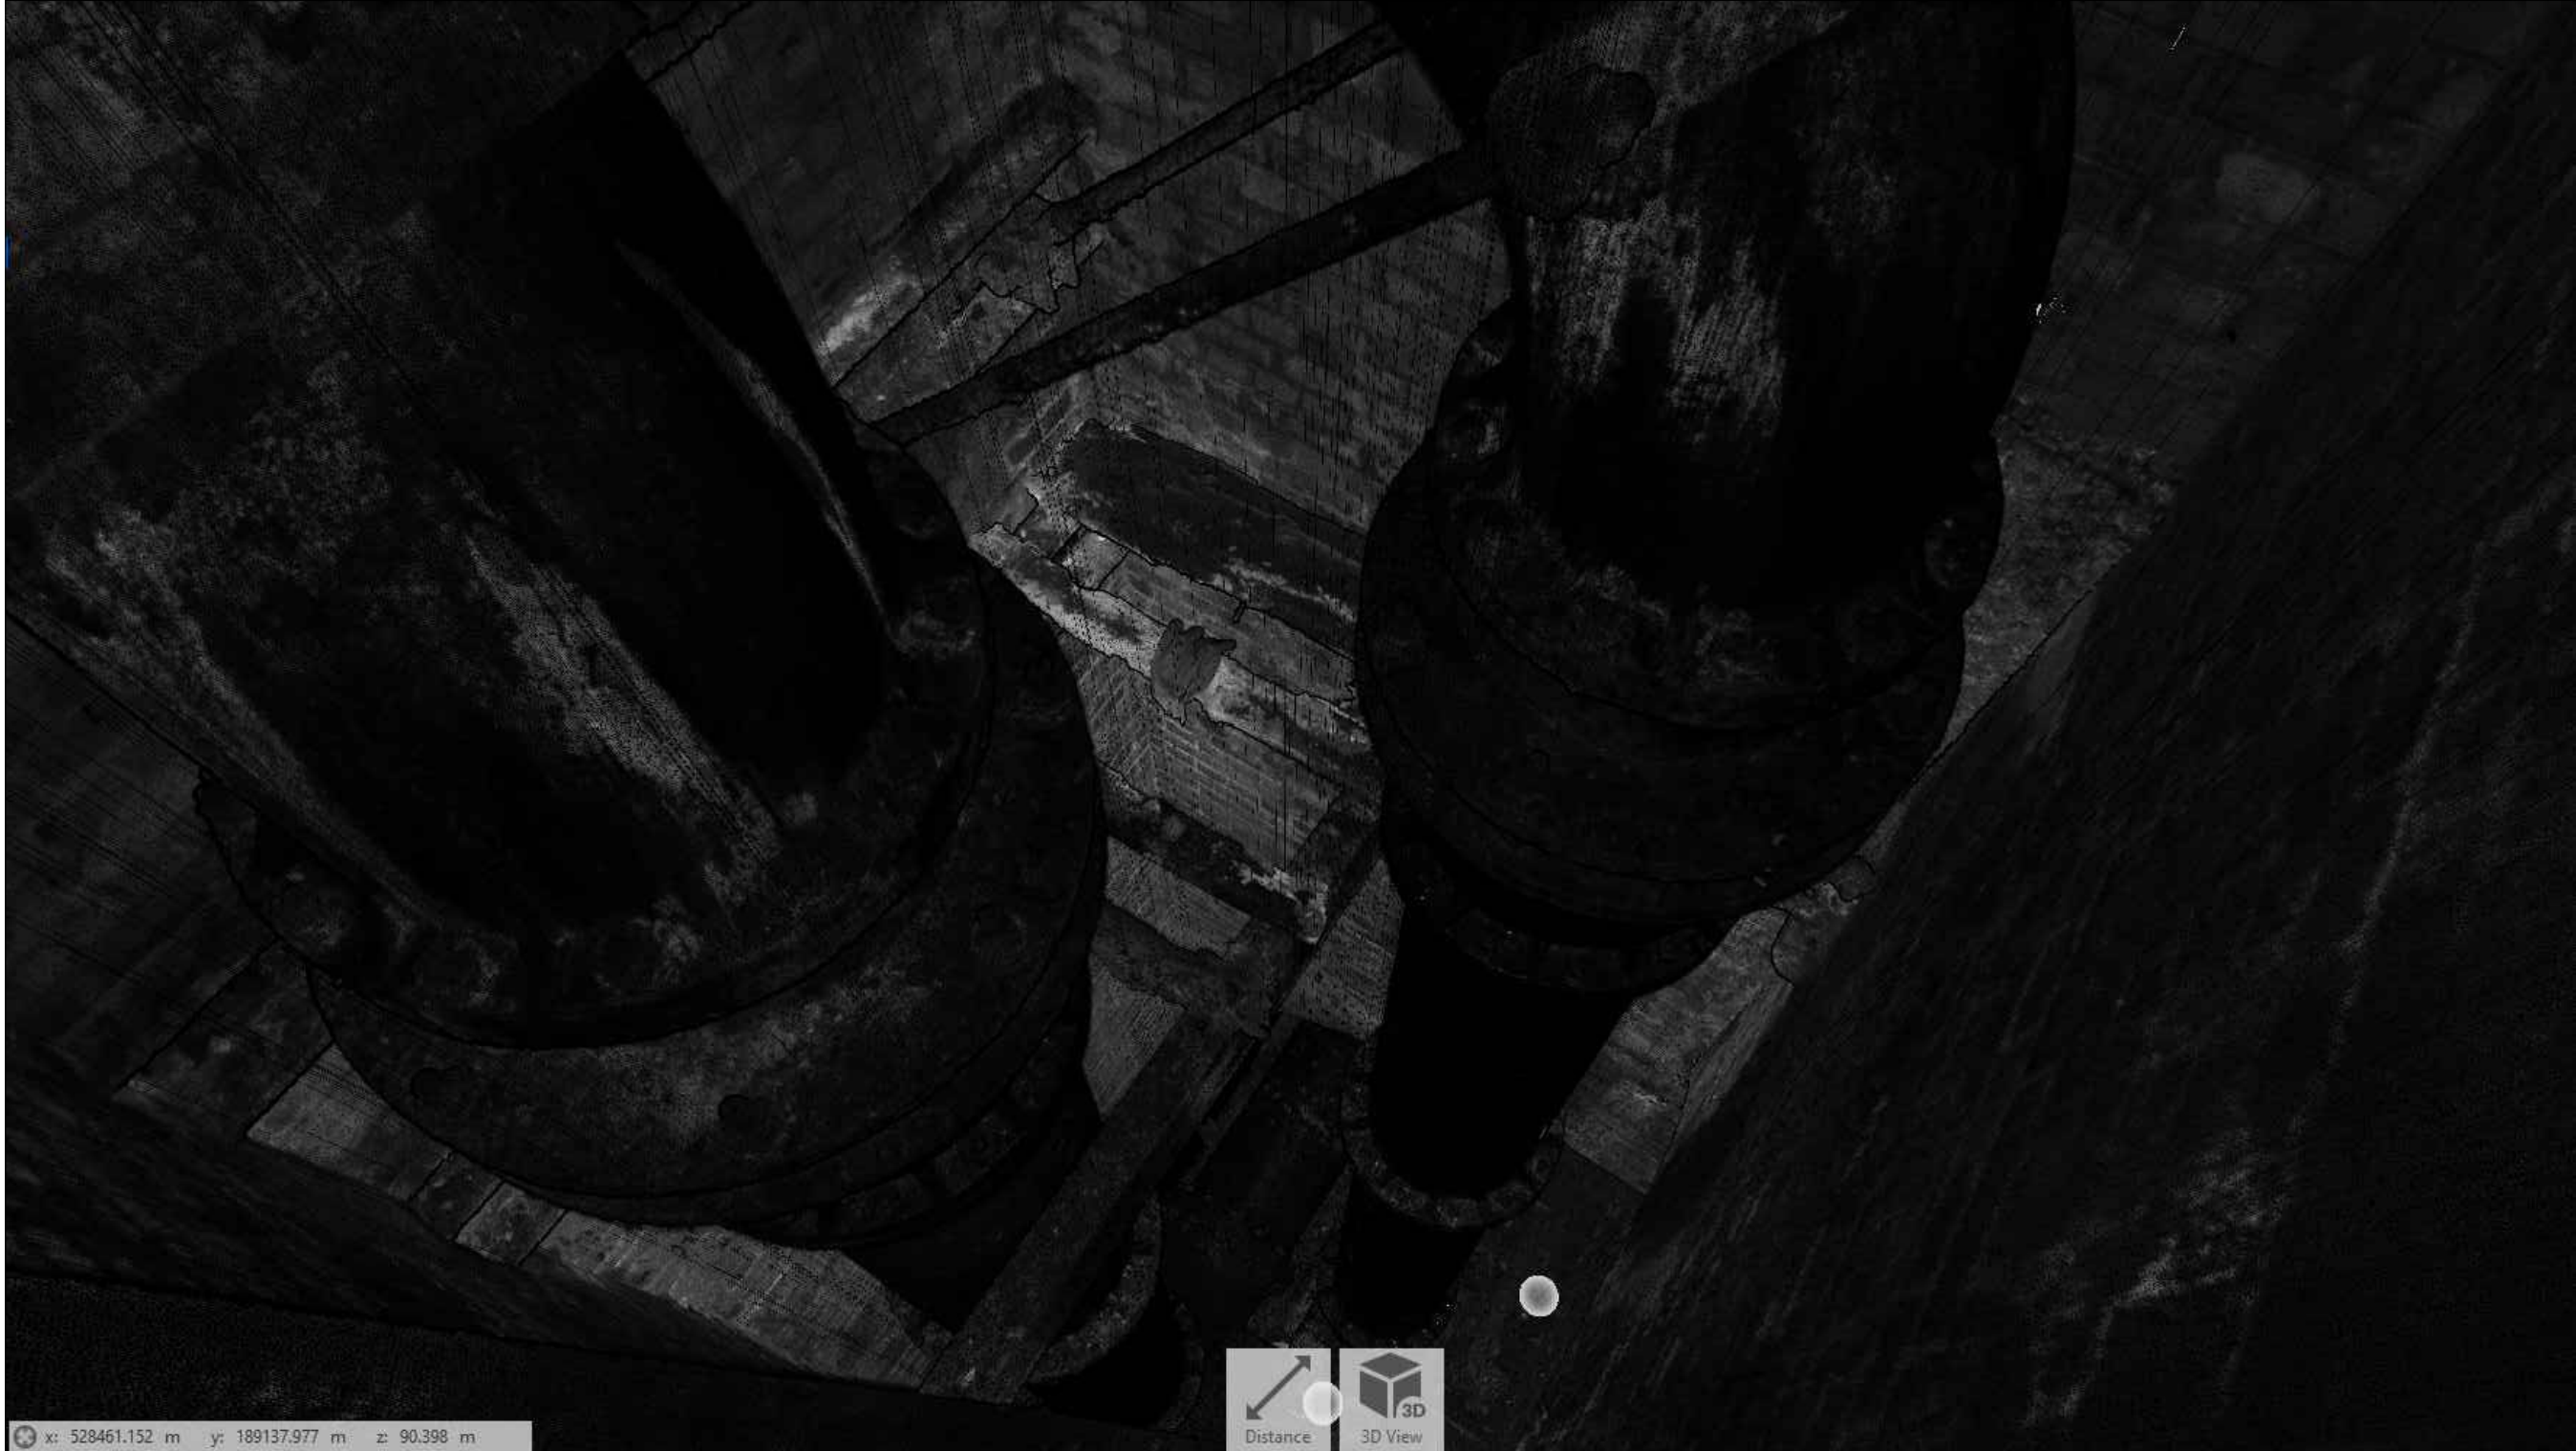

COMPUTER AIDED DRAWING - AVOID MANUAL MODIFICATION


THIS DRAWING MUST NOT BE SCALED,
ALL DIMENSIONS TO BE CHECKED ON SITE.

DISCLAIMER
The information shown within is given without obligation, or warranty, the accuracy thereof cannot be guaranteed. No liability of any kind whatsoever is accepted by Cable Tracing Services Limited its operatives for any error or omission.
Safe digging practices, in accordance with HS(G)47 must be used to verify and establish the actual position of the statutory undertaker's apparatus on site before any mechanical plant is used. It is your responsibility to ensure that this information is provided to all persons either direct labour or contractors. Any error found should be reported immediately to the management before any works are to be carried out.


Notes

This 3D Model has been drawn from point cloud data taken from the inside surfaces of the sewer structures.

ALL MEASUREMENTS ARE APPROXIMATE AND SHOULD BE VERIFIED ON SITE BY FOLLOWING THE SAFE DIGGING PRACTICES SET OUT IN THE HSG47 GUIDE. COORDINATE SYSTEM SETTINGS: SYSTEM - UNITED KINGDOM ZONE - OS NATIONALGRID(OSTN02) DATUM - ORDNANCE SURVEY GEOID MODEL - (OSGM02) COORDINATE ORDER - EAST FIRST - NORTH LAST REFERENCE DRAWINGS.				
DRAWING No		TITLE		
Project Title:				
Cranwood House				
Client:				
McAllister Group				
Discipline: Topographical Survey & Laser Scanning			Scale: NTS	Project Phase: Survey Information
Drawing Originator: Cable Tracing Services Limited			Drawn By: DMB	Approval By: JMB
Drawing No: CTS-MC 0129 20-21(4)		Revision: B	Drawn Date: 15-12-20	Check Date: 17-06-21

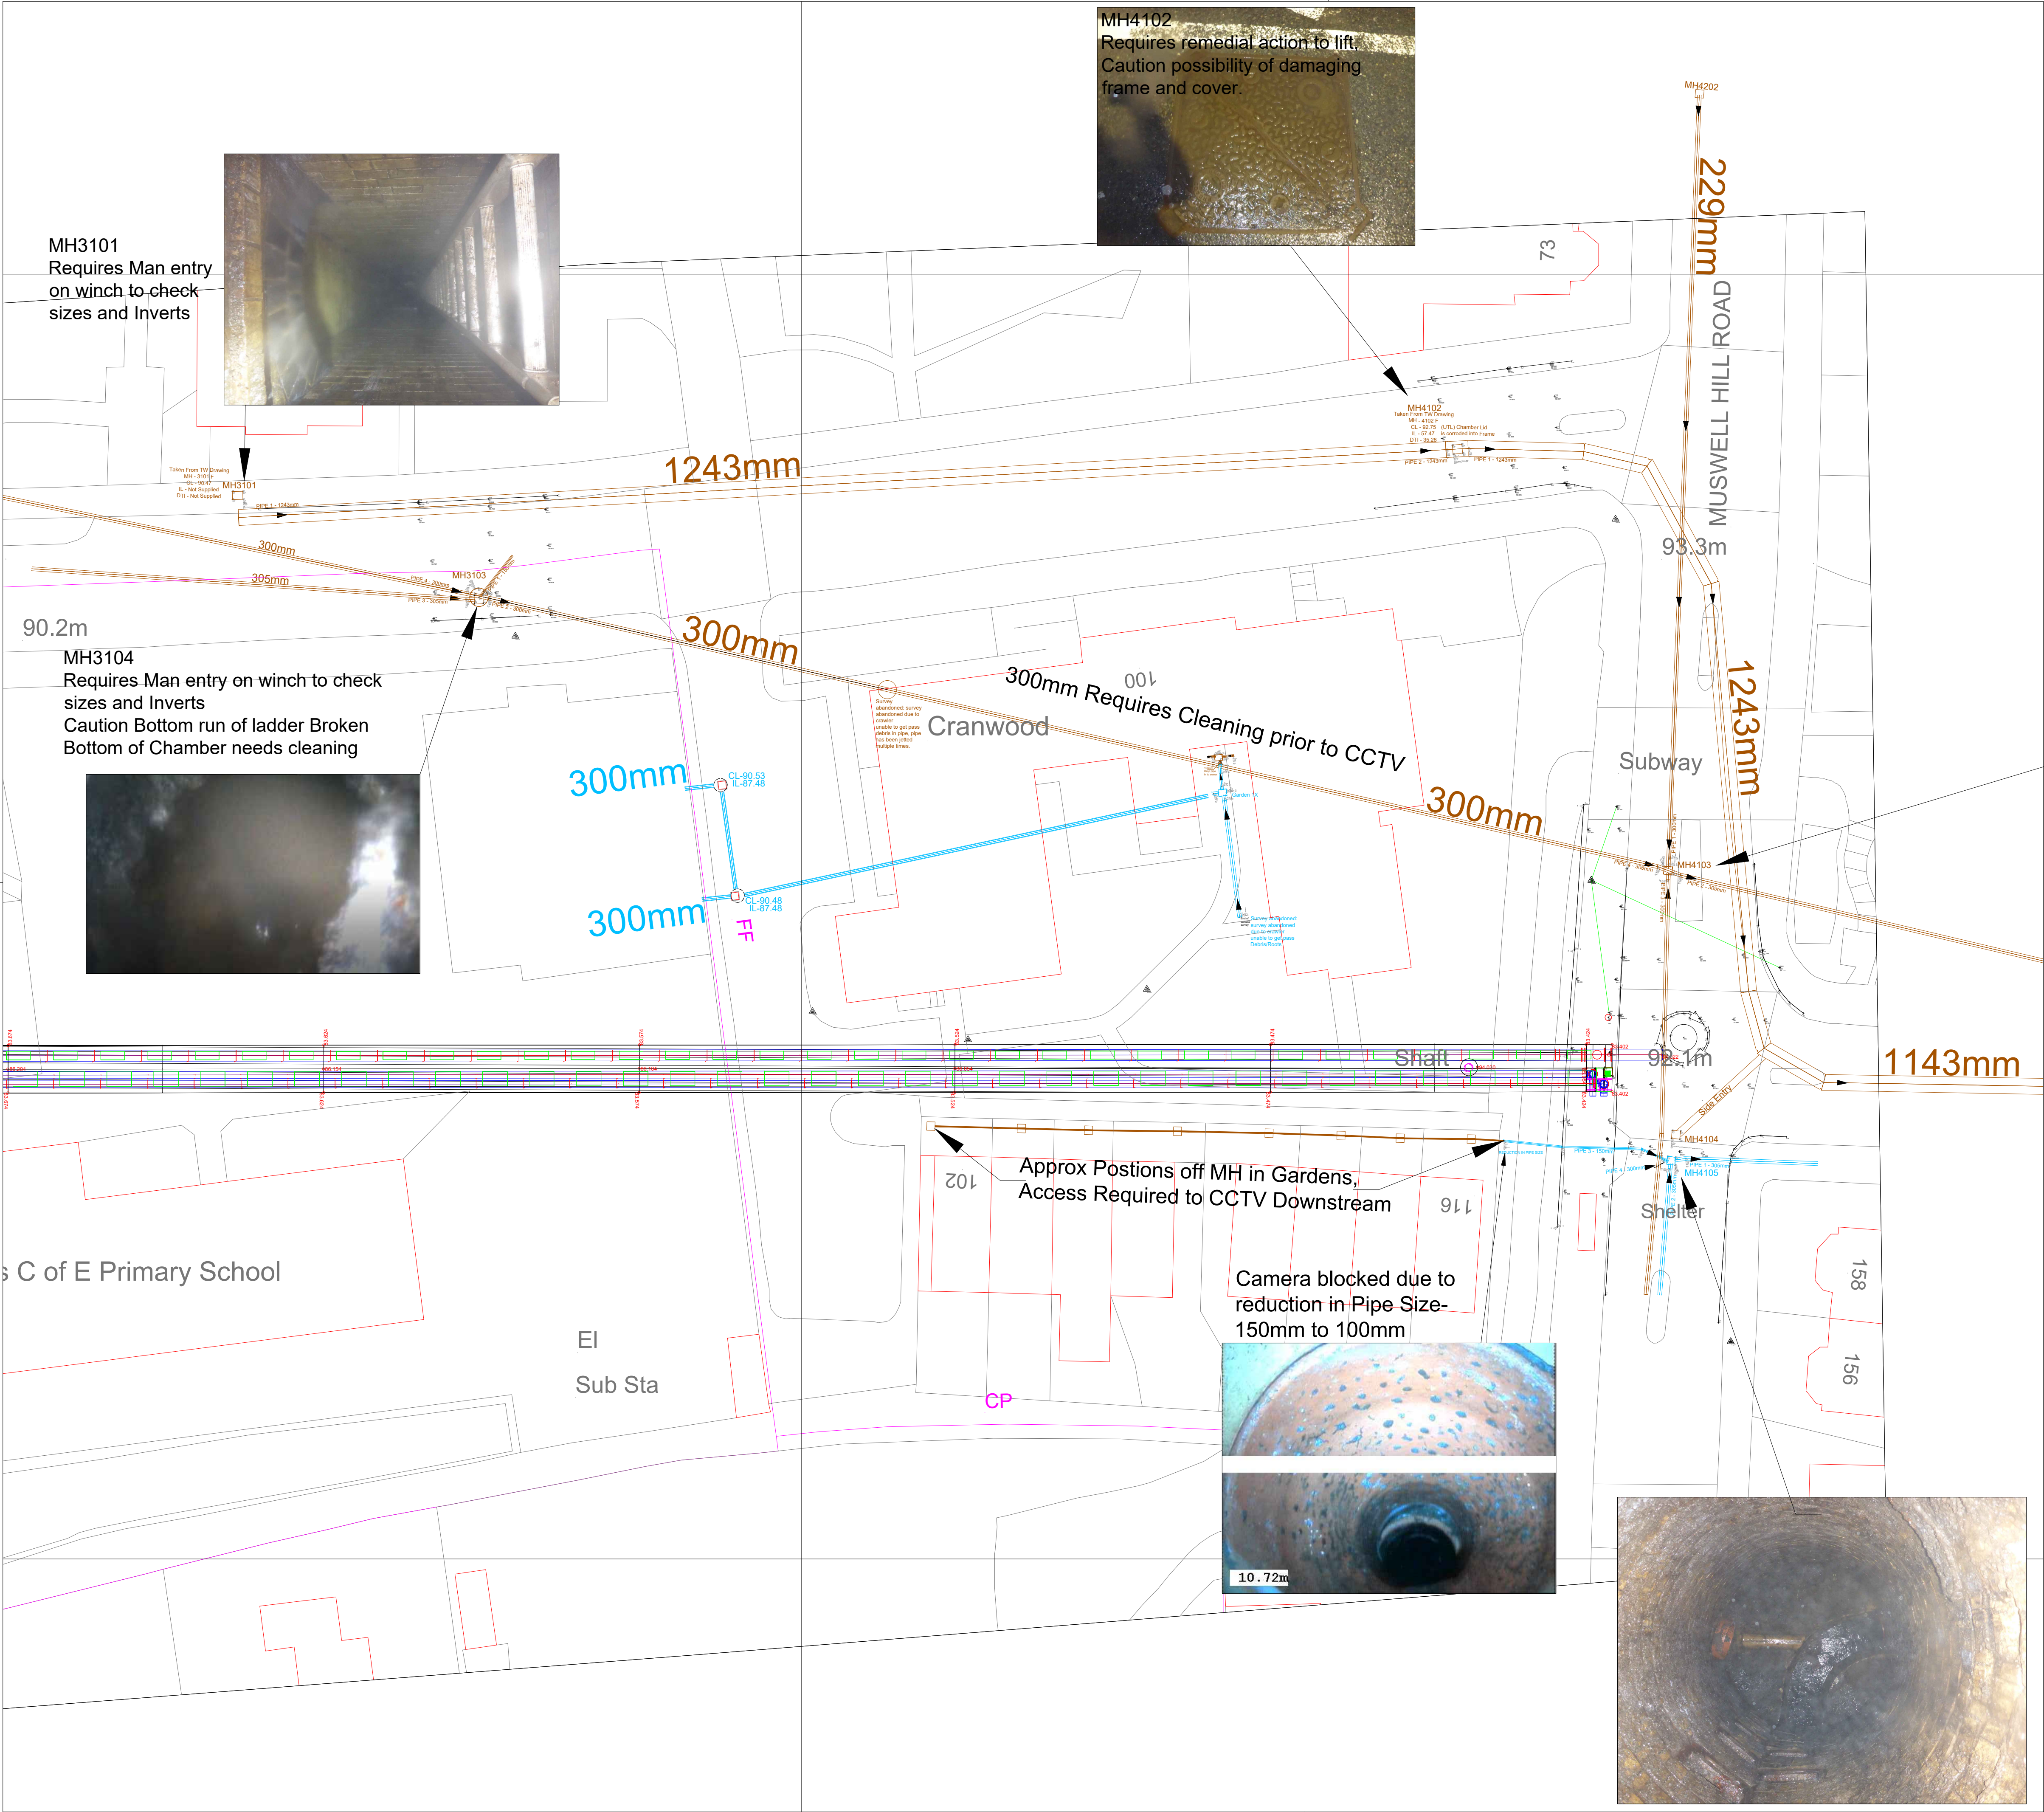

MH3101
Requires Man entry
on winch to check
sizes and Inverts

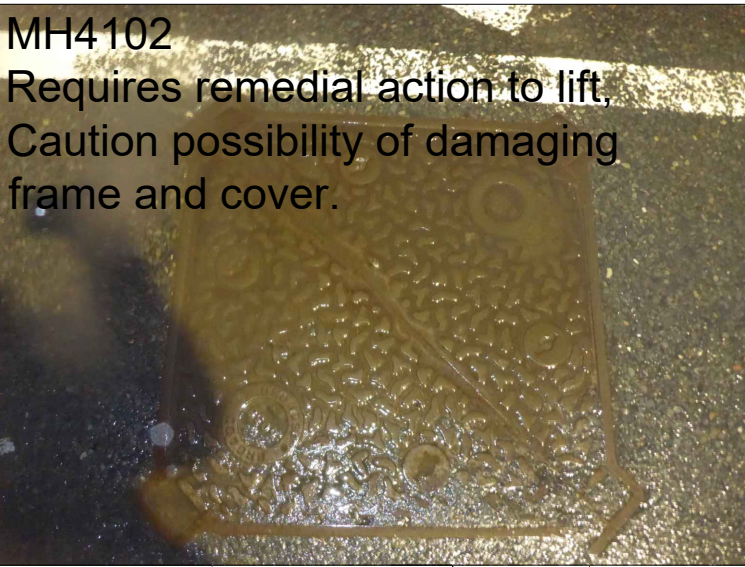

MH4102
Requires remedial action to lift.
Caution possibility of damaging
frame and cover.

MH3104
Requires Man entry on winch to check
sizes and Inverts
Caution Bottom run of ladder Broken
Bottom of Chamber needs cleaning



Cranwood


300mm Requires Cleaning prior to CCTV

Subway

300mm

Approx Postions off MH in Gardens,
Access Required to CCTV Downstream

Camera blocked due to
reduction in Pipe Size-
150mm to 100mm

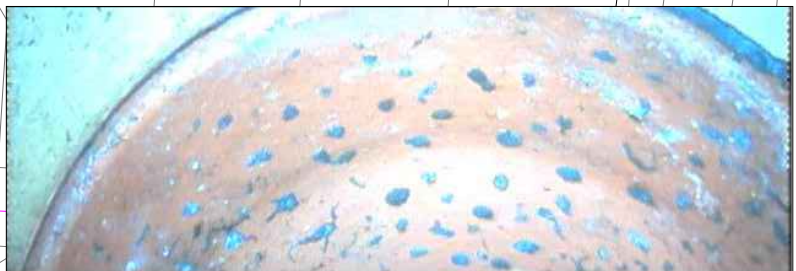


10.72m




COMPUTER AIDED DRAWING - AVOID MANUAL MODIFICATION
THIS DRAWING MUST NOT BE SCALED,
ALL DIMENSIONS TO BE CHECKED ON SITE.

DISCLAIMER
The information shown within is given without obligation, or warranty, the accuracy thereof cannot be guaranteed. No liability of any kind whatsoever is accepted by Cable Tracing Services Limited its operatives for any error or omission.
Safe digging practices, in accordance with HSG47 must be used to verify and establish the actual position of the statutory undertaker's apparatus on site before any mechanical plant is used. It is your responsibility to ensure that this information is provided to all persons either direct labour or contractors. Any error found should be reported immediately to the management before any works are to be carried out.

Notes
This 3D Model has been drawn
from point cloud data taken from
the inside surfaces of the sewer
structures.

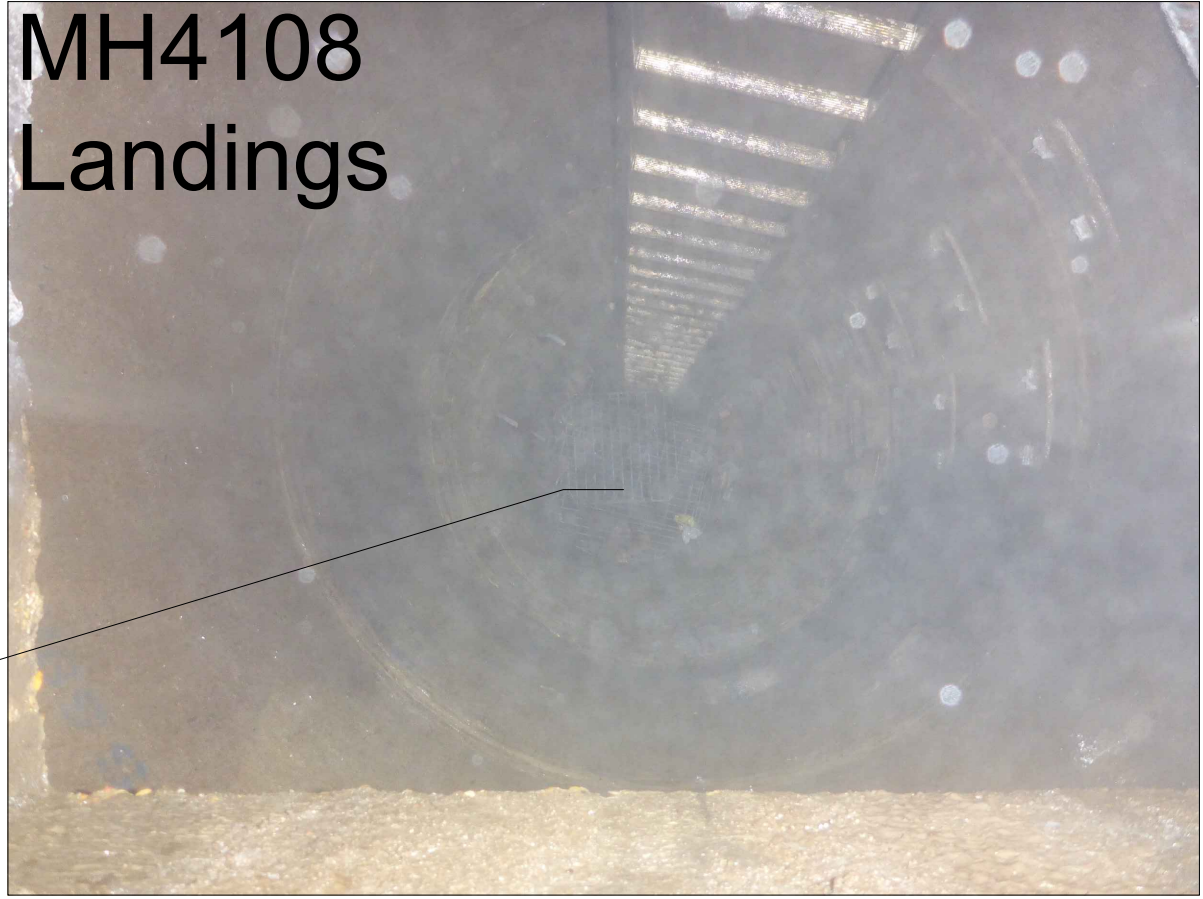

MH4108
Landings

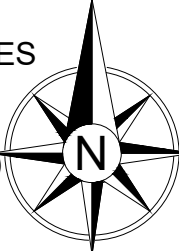ALL MEASUREMENTS ARE APPROXIMATE AND SHOULD BE VERIFIED ON SITE BY FOLLOWING THE SAFE DIGGING PRACTICES SET OUT IN THE HSG47 GUIDE. COORDINATE SYSTEM SETTINGS: SYSTEM - UNITED KINGDOM ZONE - OS NATIONALGRID(OSTN02) DATUM - ORDNANCE SURVEY GEOID MODEL - (OSGM02) COORDINATE ORDER - EAST FIRST - NORTH LAST REFERENCE DRAWINGS.				
DRAWING No		TITLE		
Project Title:				
Cranwood House				
Client:				
McAllister Group				
Discipline: Topographical Survey & Laser Scanning		Scale: 1:250@ A1	Project Phase: Survey Information	
Drawing Originator: Cable Tracing Services Limited		Drawn By: AMB	Approval By: JMB	
Drawing No: CTS-MC 0129 20-21(5)		Revision: C	Drawn Date: 15-12-20	Check Date: 17-06-21